




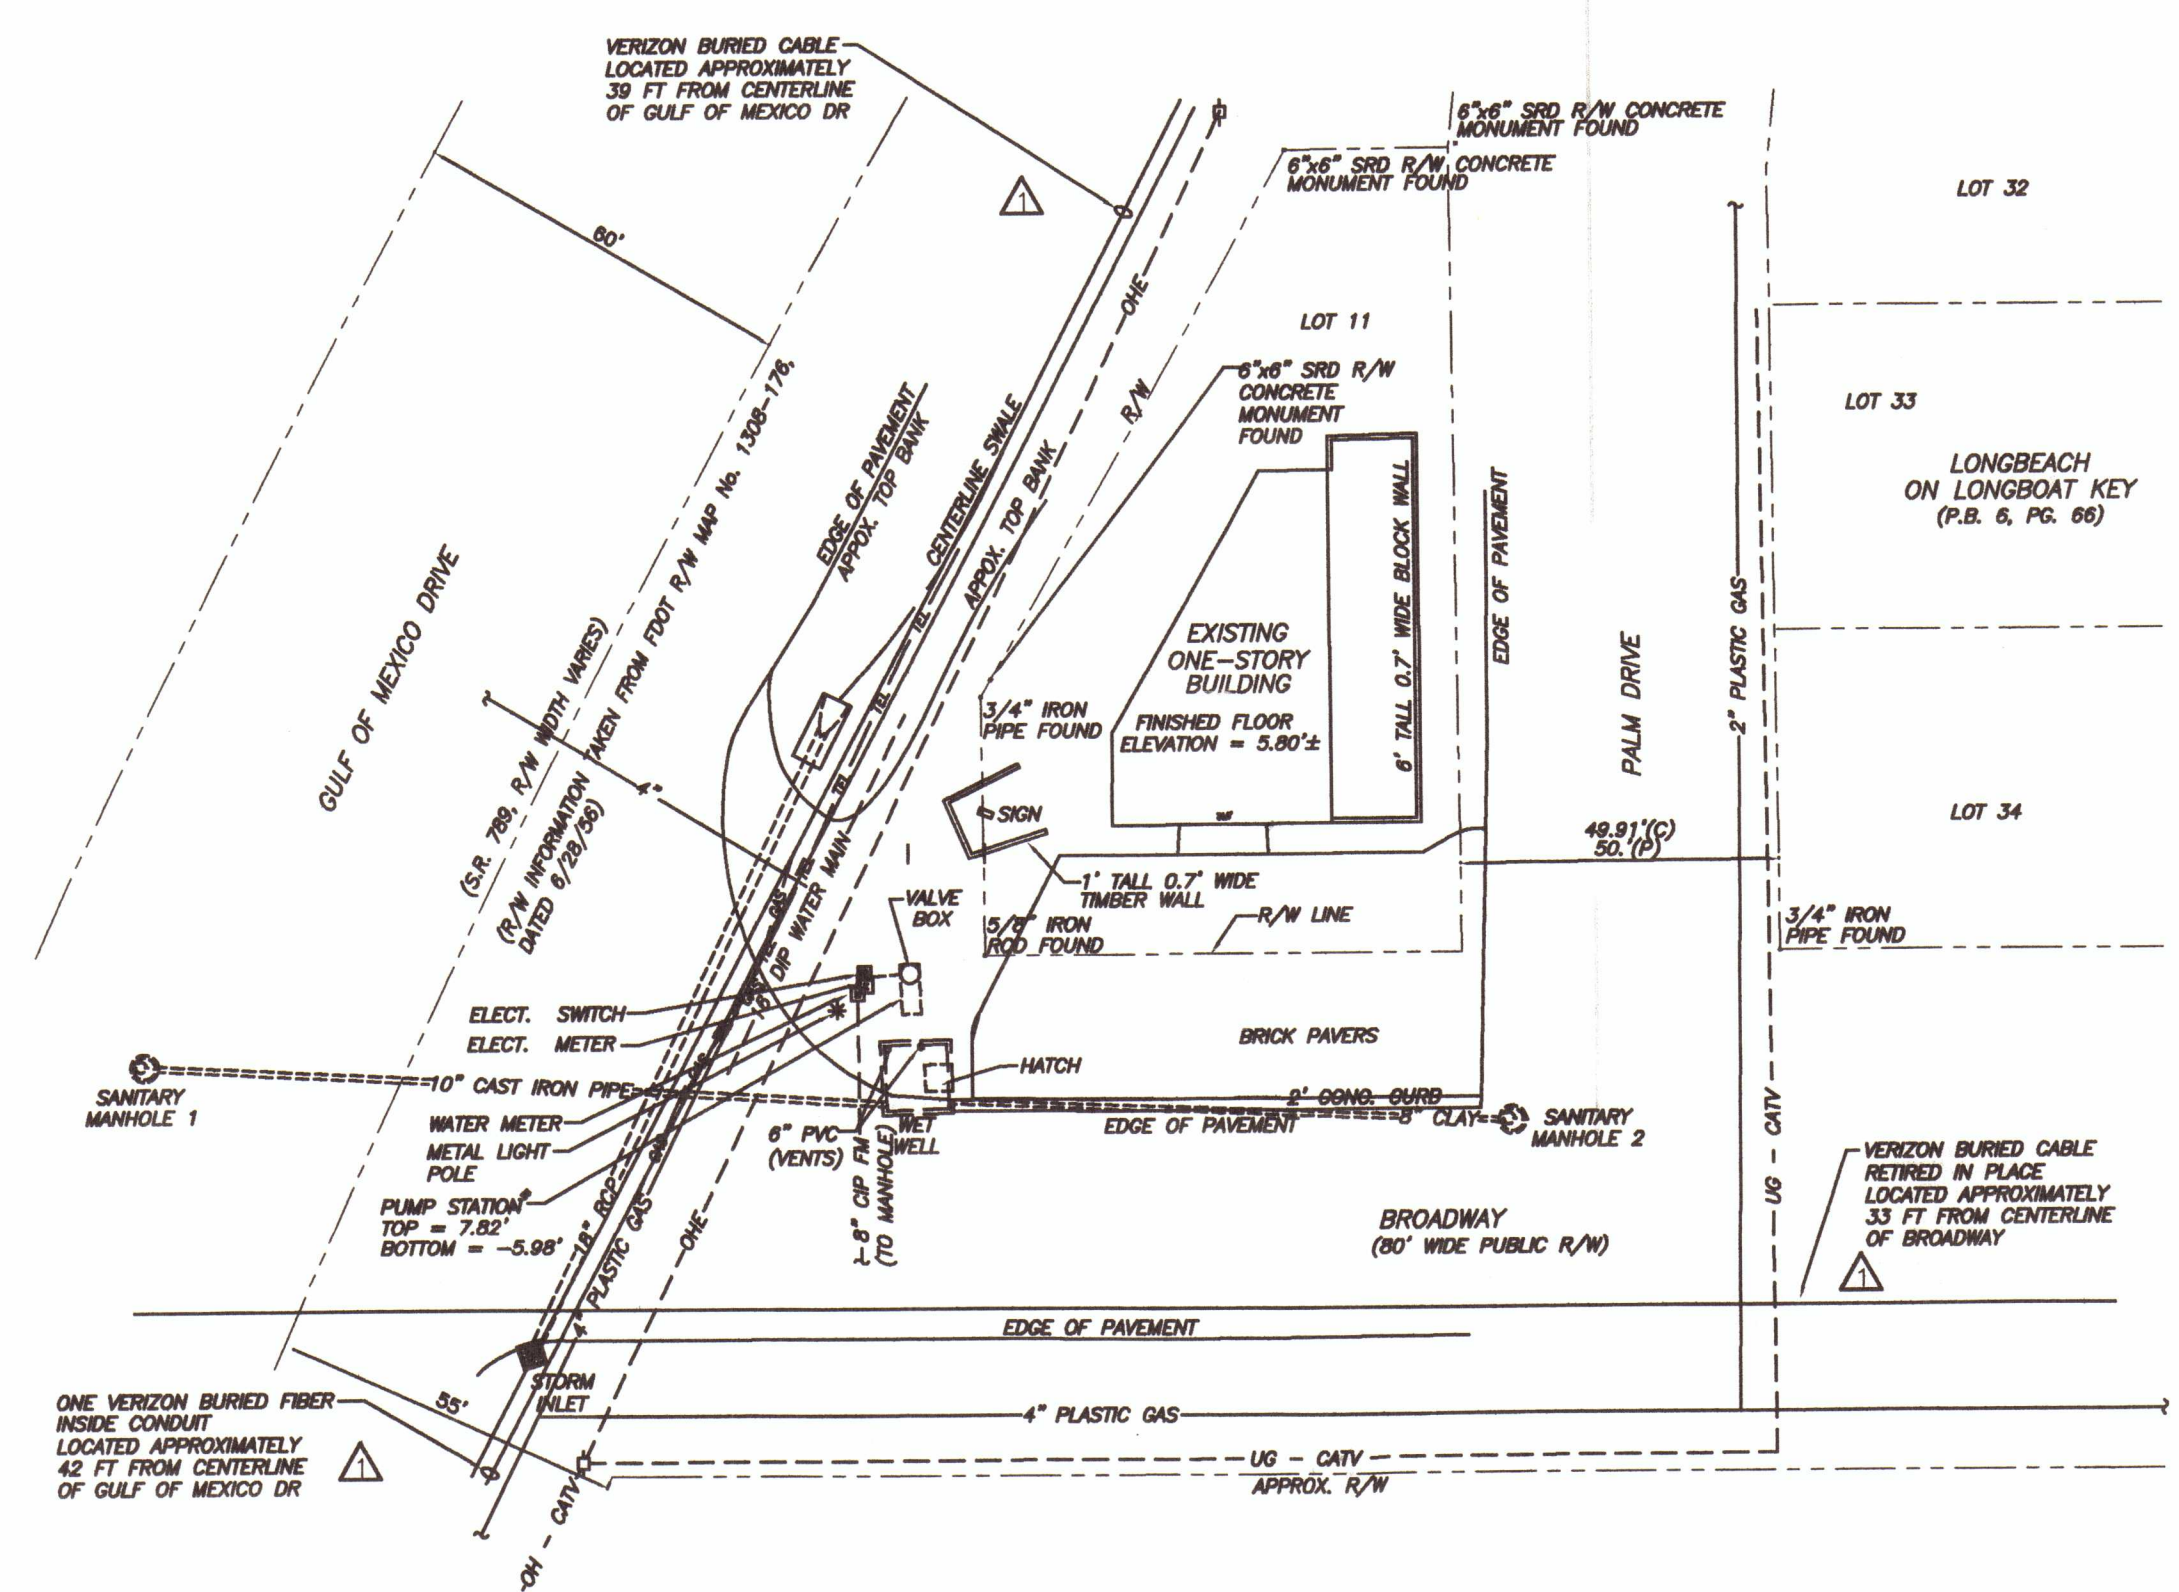

EXISTING SITE PLAN

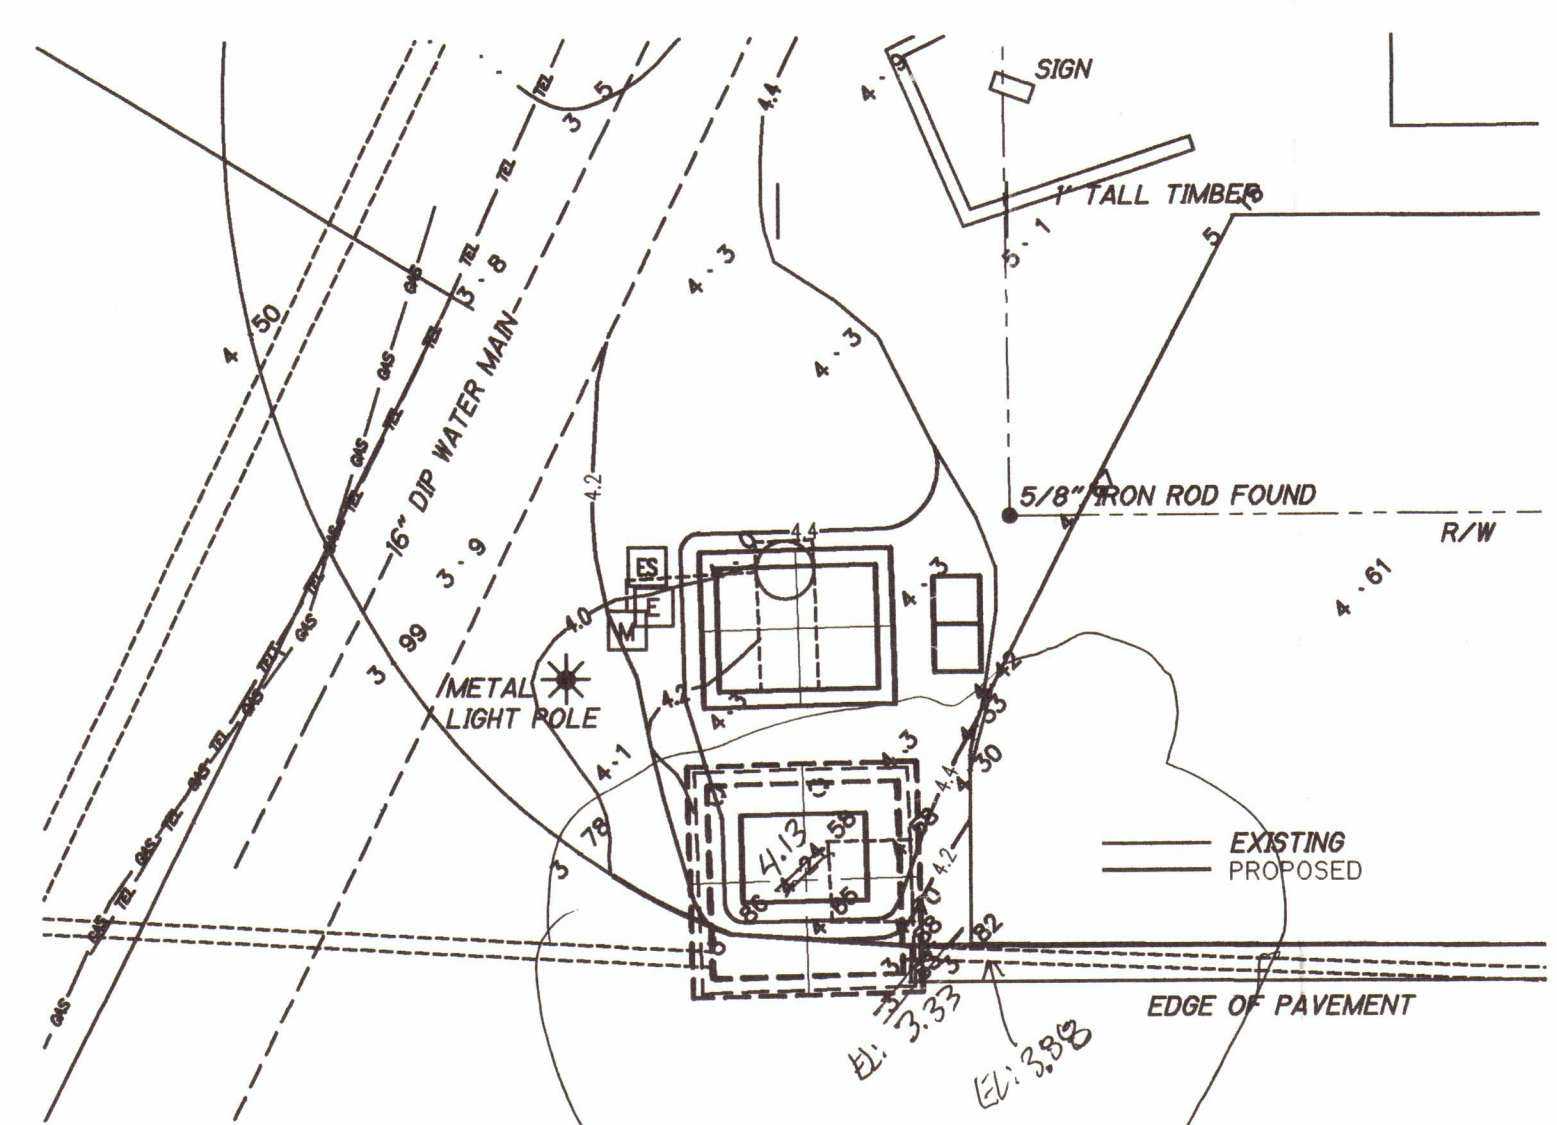

GRADING PLAN

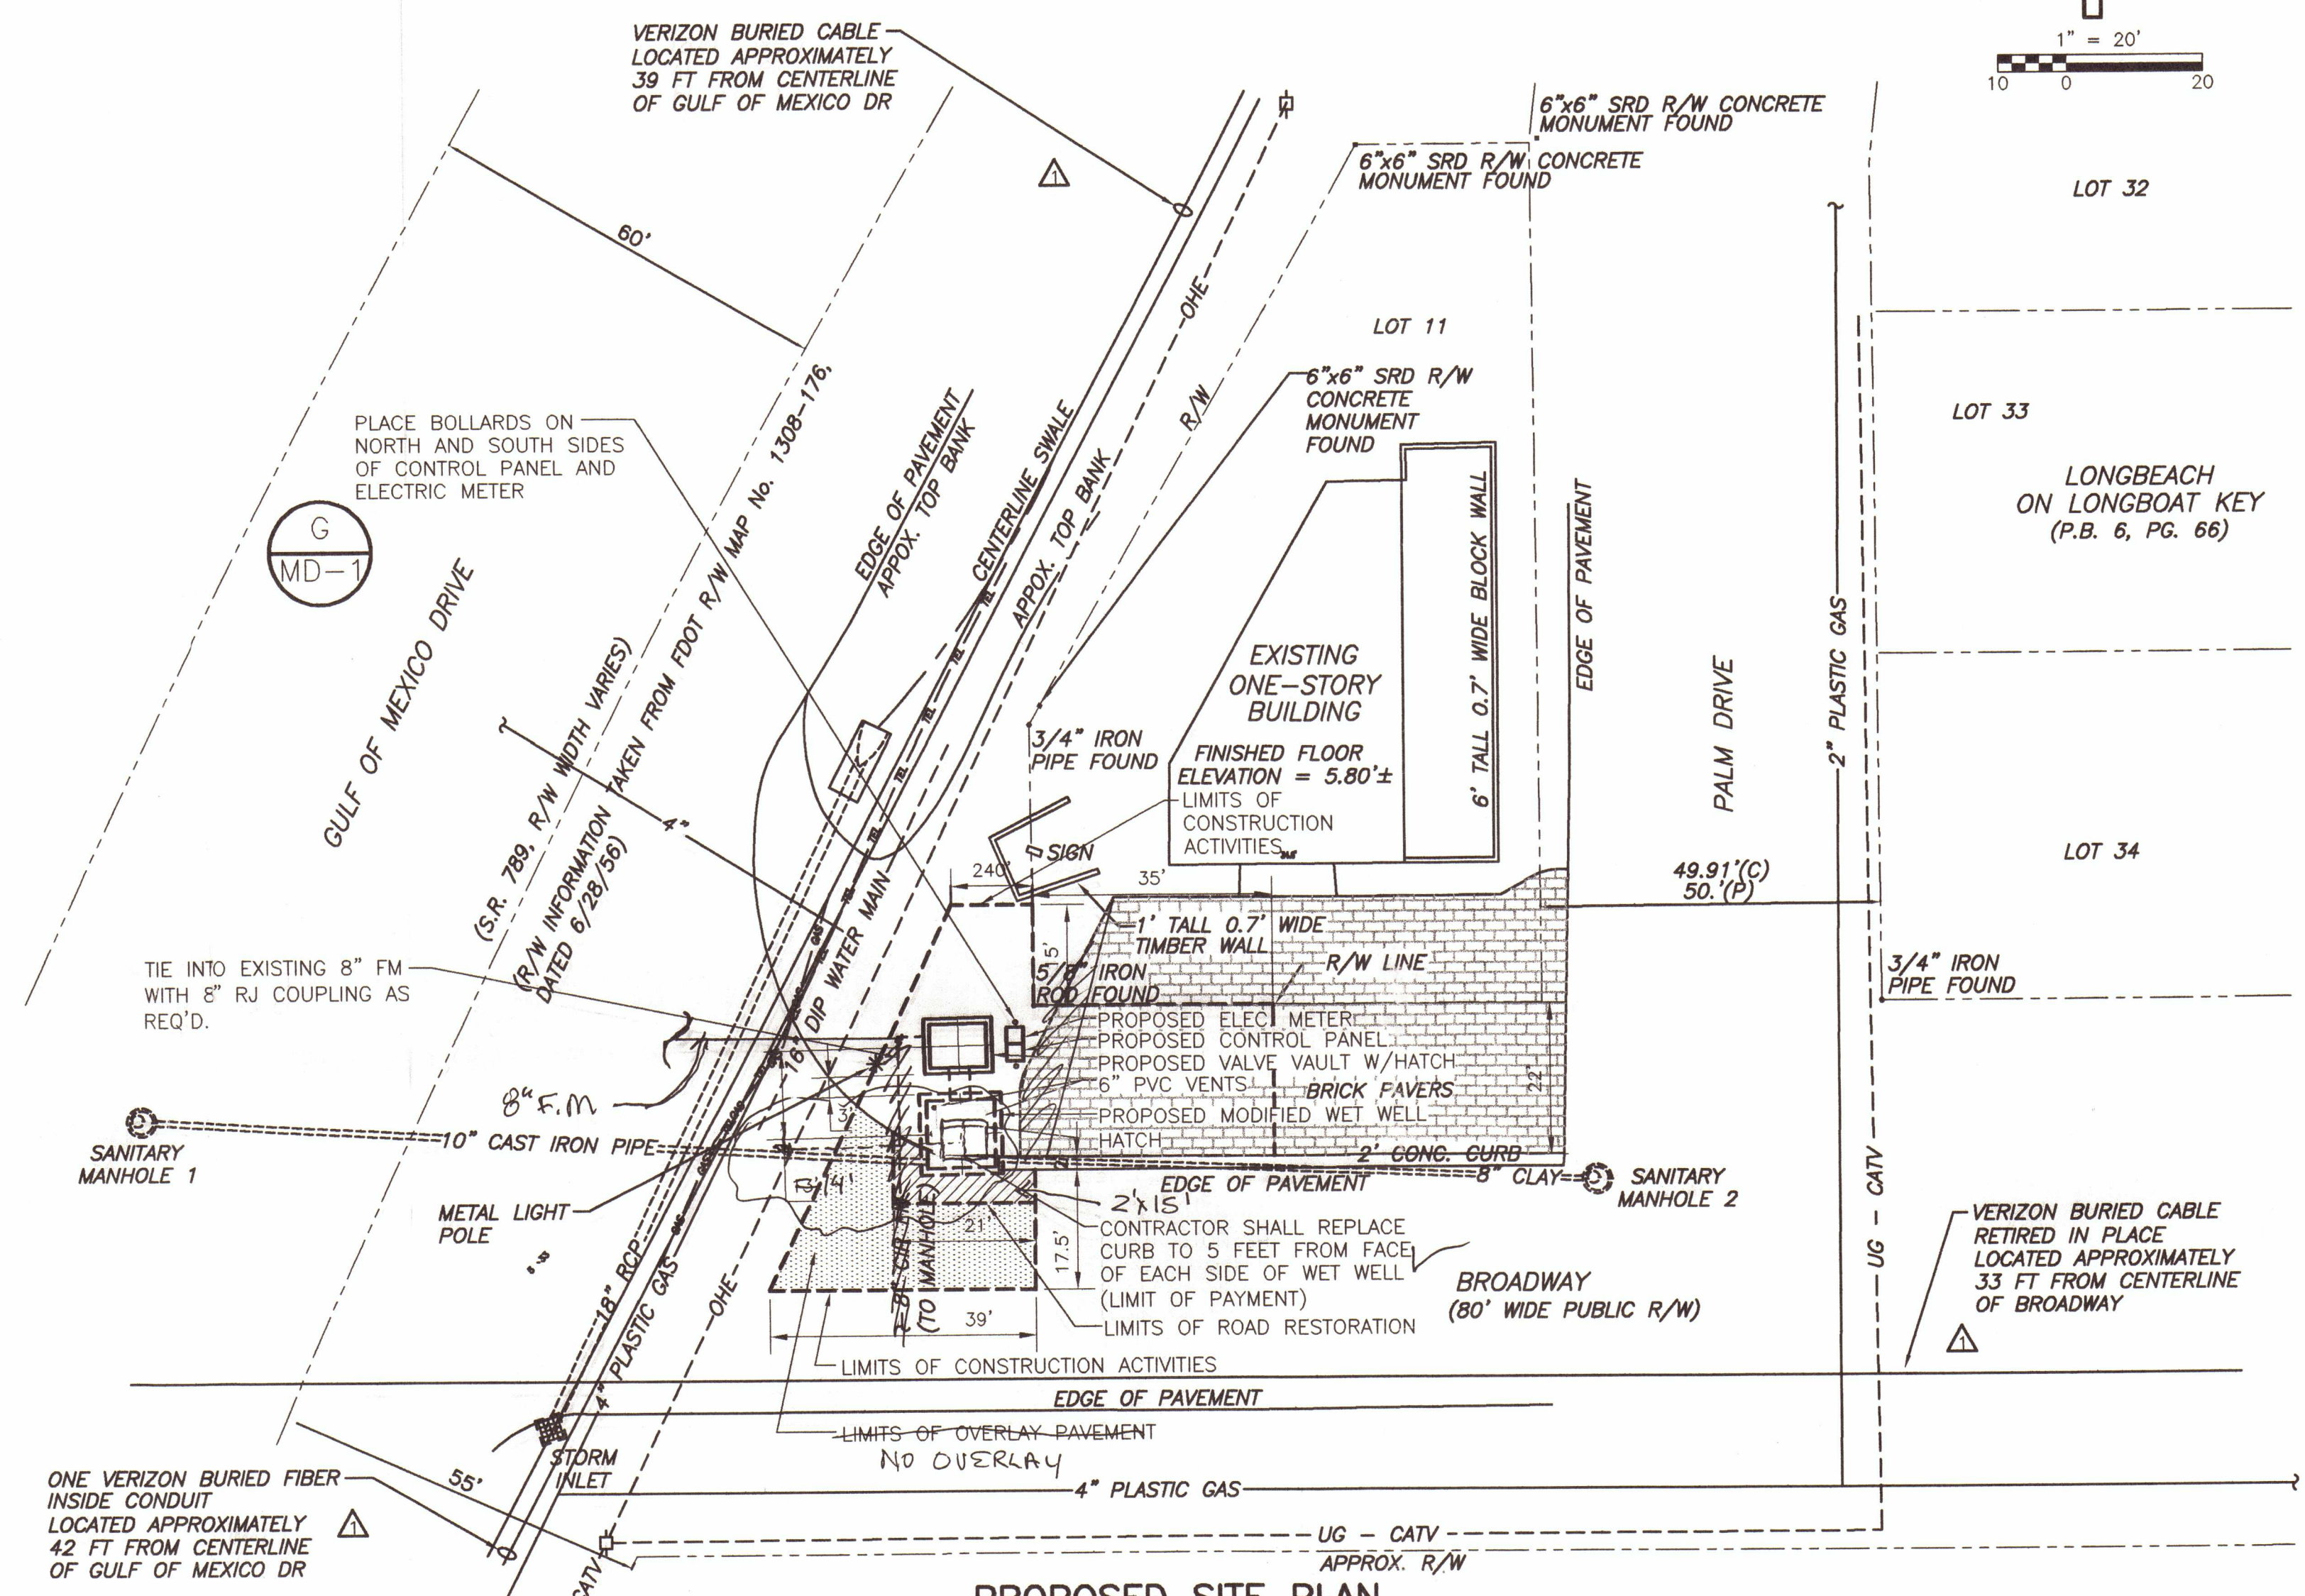

PROPOSED SITE PLAN

NOTES:

- TWO BURIED TELEPHONE LINES RUNNING EAST/WEST LOCATED ON BROADWAY NORTH RIGHT-OF-WAY. ONE IS LIVE 50 PAIR CABLE AND ONE IS ABANDONED IN PLACE. VERIZON DOES NOT HAVE LOCATION VERIFICATION. CONTRACTOR TO FIELD LOCATE.
- 8" CAST IRON FORCE MAIN LOCATION SHOWN AS APPROXIMATE FROM TOWN OF LONGBOAT KEY WASTEWATER SYSTEM DRAWINGS, 1975. CONTRACTOR TO FIELD LOCATE AND VERIFY.
- TOWN TO INSTALL WATER SERVICE/HOSE BIB. CONTRACTOR TO COORDINATE WITH TOWN.
- CONTRACTOR TO PROTECT BRICK PAVERS AND RESTORE TO PRE-CONSTRUCTION CONDITION.
- NO STOCKPILING OF MATERIAL IN ROADWAYS OR FDOT RIGHT-OF-WAY. ALL DIRT AND DEBRIS SHALL BE REMOVED FROM JOB SITE DAILY. ROADS AND SIDEWALK TO BE SWEEPED DAILY AS PART OF DAILY CLEANUP.
- CONSTRUCTION STAGING AND PARKING AREA PROVIDED ACROSS GULF OF MEXICO DRIVE AT THE BROADWAY BEACH ACCESS AREA.
- CONTRACTOR TO SEE SECTION 01014 - CONSTRUCTION RESTRAINTS.
- CONTRACTOR SHOULD LIMIT CONSTRUCTION TO BOUNDARIES SHOWN.
- MAINTENANCE OF TRAFFIC, SIGNS AND BARRICADES TO BE ACCORDING TO FDOT MANUAL OF SAFE PRACTICES. REFERENCE FDOT STANDARDS INDEXES NO. 611 AND NO. 621. CONTRACTOR MUST SUBMIT MOT, WITH ANY MODIFICATIONS TO THE OWNER AND FDOT FOR APPROVAL.
- FR&L PLANS TO RELOCATE ELECTRIC POLE LOCATED ON SOUTHEAST CORNER OF GULF OF MEXICO DRIVE AND BROADWAY. CONTRACTOR TO CONFIRM LOCATION IN THE FIELD.

TLC Diversified, Inc.
APPROVED
Date 5-7-04 By *[Signature]*

CONFORMED DRAWINGS
NOVEMBER 2003

SITE PLANS

JAN 9 2004

[Signature]
ANNE L. ROSS
P.E. NO. 56976
11/18/03

PROJECT NO. 2790-38413
FILE NAME: CSTPL001.dwg

SHEET NO. C-1
APPLICANT


CDM Camp Dresser & McKee Inc.
1819 Main Street, Suite 1002
Sarasota, Florida 34236
Tel: 941-363-9696
FL Cert. of Authorization No. 20

DESIGNED BY: W. SPRIGGS
DRAWN BY: J. SANCIMINO
SHEET CHK'D BY: A. ROSS
CROSS CHK'D BY: G. CASHON
APPROVED BY: A. ROSS
DATE: AUGUST 2003

REV. NO.	DATE	DRWN	CHKD	REMARKS
11/03	JAS	WMS		CONFORMED DRAWINGS
9/03	JAS	WMS		ADDENDUM NO. 1

TOWN OF LONGBOAT KEY, FLORIDA

LIFT STATION A IMPROVEMENTS

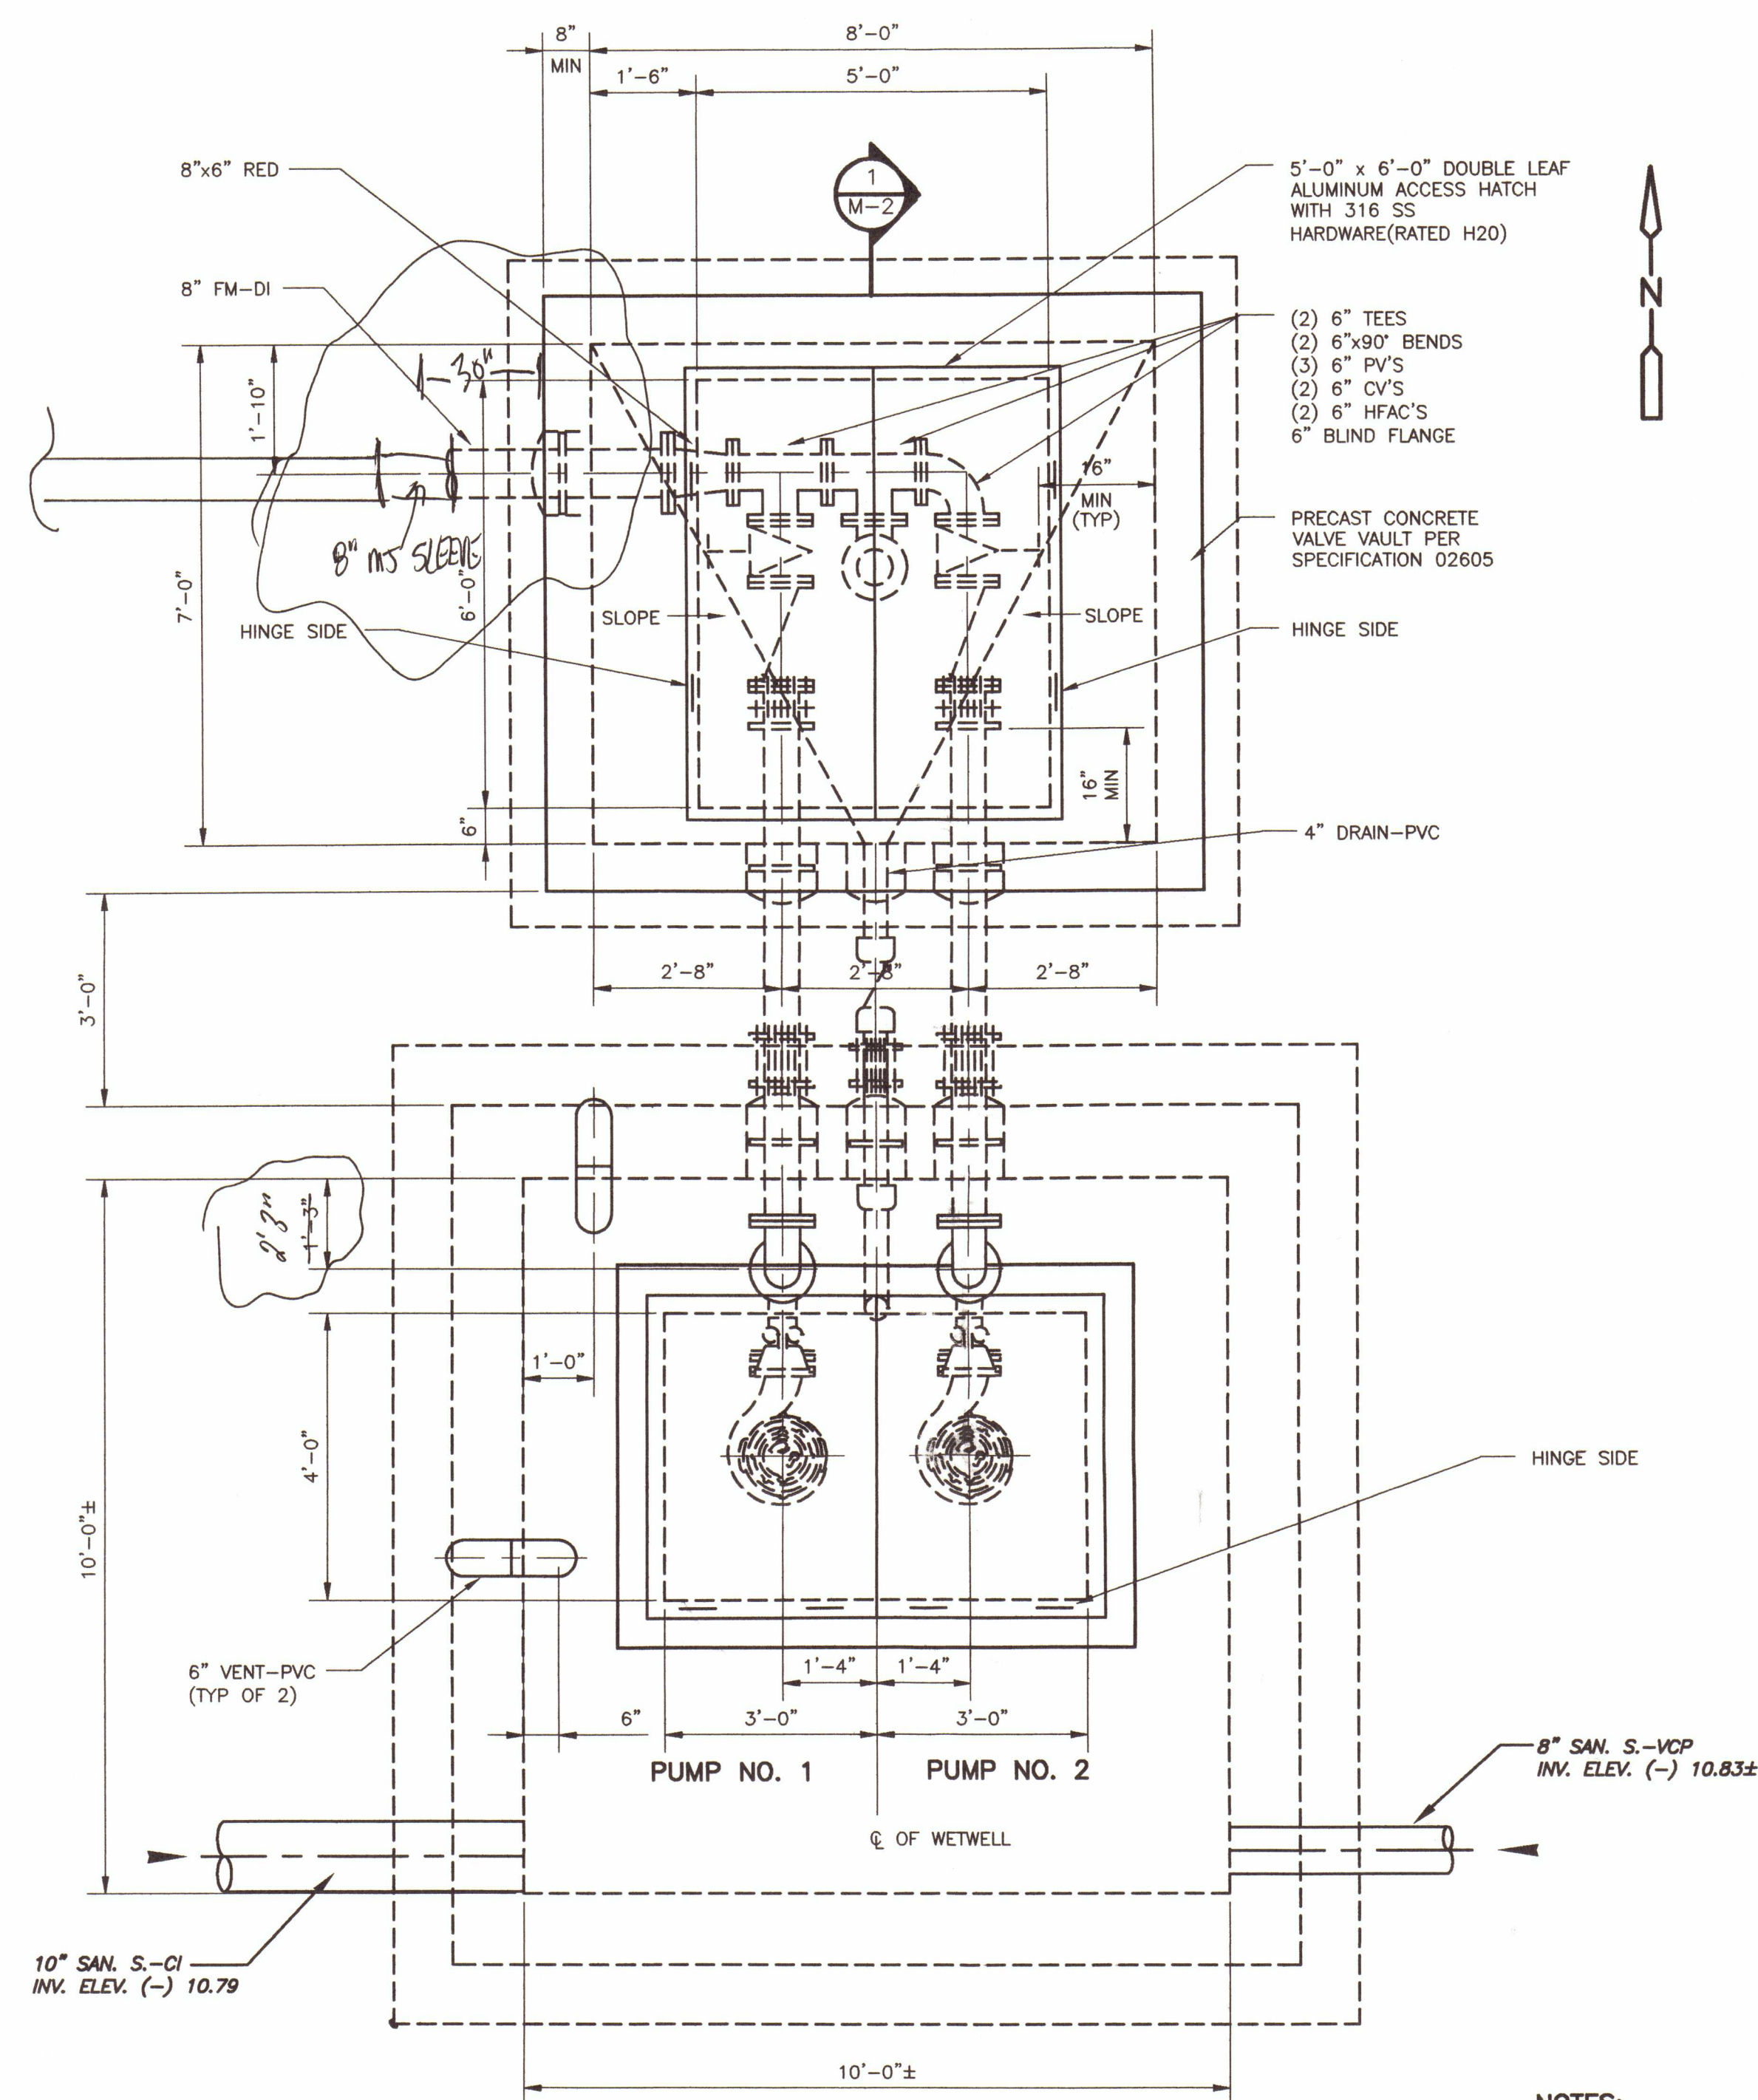


PLAN

1/2" = 1'-0"

NOTES:

- THE WALLS OF THE WETWELL SHALL BE BLAST CLEANED, REMOVING ALL GREASE, DIRT AND ALL OTHER CONTAMINATES THAT MAY INHIBIT BONDING. ALL LOOSE AND DETERIORATED CONCRETE SHALL BE REMOVED TO SOUND CONCRETE. RESTORE ALL CONCRETE TO ORIGINAL THICKNESS USING A FAST SETTING, HIGH EARLY STRENGTH PORTLAND CEMENT BASED RESURFACING MATERIAL. REFER TO SPECIFICATION NO. 03180 AND NO. 03700.
- REFER TO SPECIFICATION NO. 02605 FOR PRECAST STRUCTURES.
- ALL PUMPING STATION WORK SHALL CONFORM TO THE REQUIREMENTS TO THE APPROPRIATE SECTIONS OF THE SPECIFICATIONS.
- ALL EQUIPMENT, ANCHOR BOLT SIZES, LOCATIONS, CLEARANCES, ETC., SHALL BE IN CONFORMANCE WITH THE MANUFACTURER'S RECOMMENDATIONS AND THE APPROVED SHOP DRAWINGS.
- PUMP ACCESS HATCH CONFIGURATION AND DIMENSIONS SHALL BE CONFIRMED WITH EQUIPMENT SUPPLIER. DIMENSIONS SHOWN ARE MINIMUM VALUES ONLY. HATCH TO BE H20 RATED.
- WET WELL TOP SLAB AND VALVE VAULT SHALL BE PRE-CAST REINFORCED CONCRETE.
- SMITH BLAIR (TYPE 913) OR DRESSER (STYLE 127) OR EQUAL CI FLANGED ADAPTER COUPLING AND HARNESS WITH A MINIMUM OF TWO 3/4" 316 SS TIE RODS.
- SEE ELECTRICAL SHEETS FOR LOCATION OF CONTROL PANEL AND CONNECTING CONDUITS.
- TYPE 316 STAINLESS STEEL SHALL BE USED INSIDE AND OUTSIDE OF WET WELL AND VALVE VAULT FOR FLANGE NUTS, BRACKETS, GUIDE RAILS AND ALL OTHER HARDWARE EXCEPT AS OTHERWISE SPECIFIED.

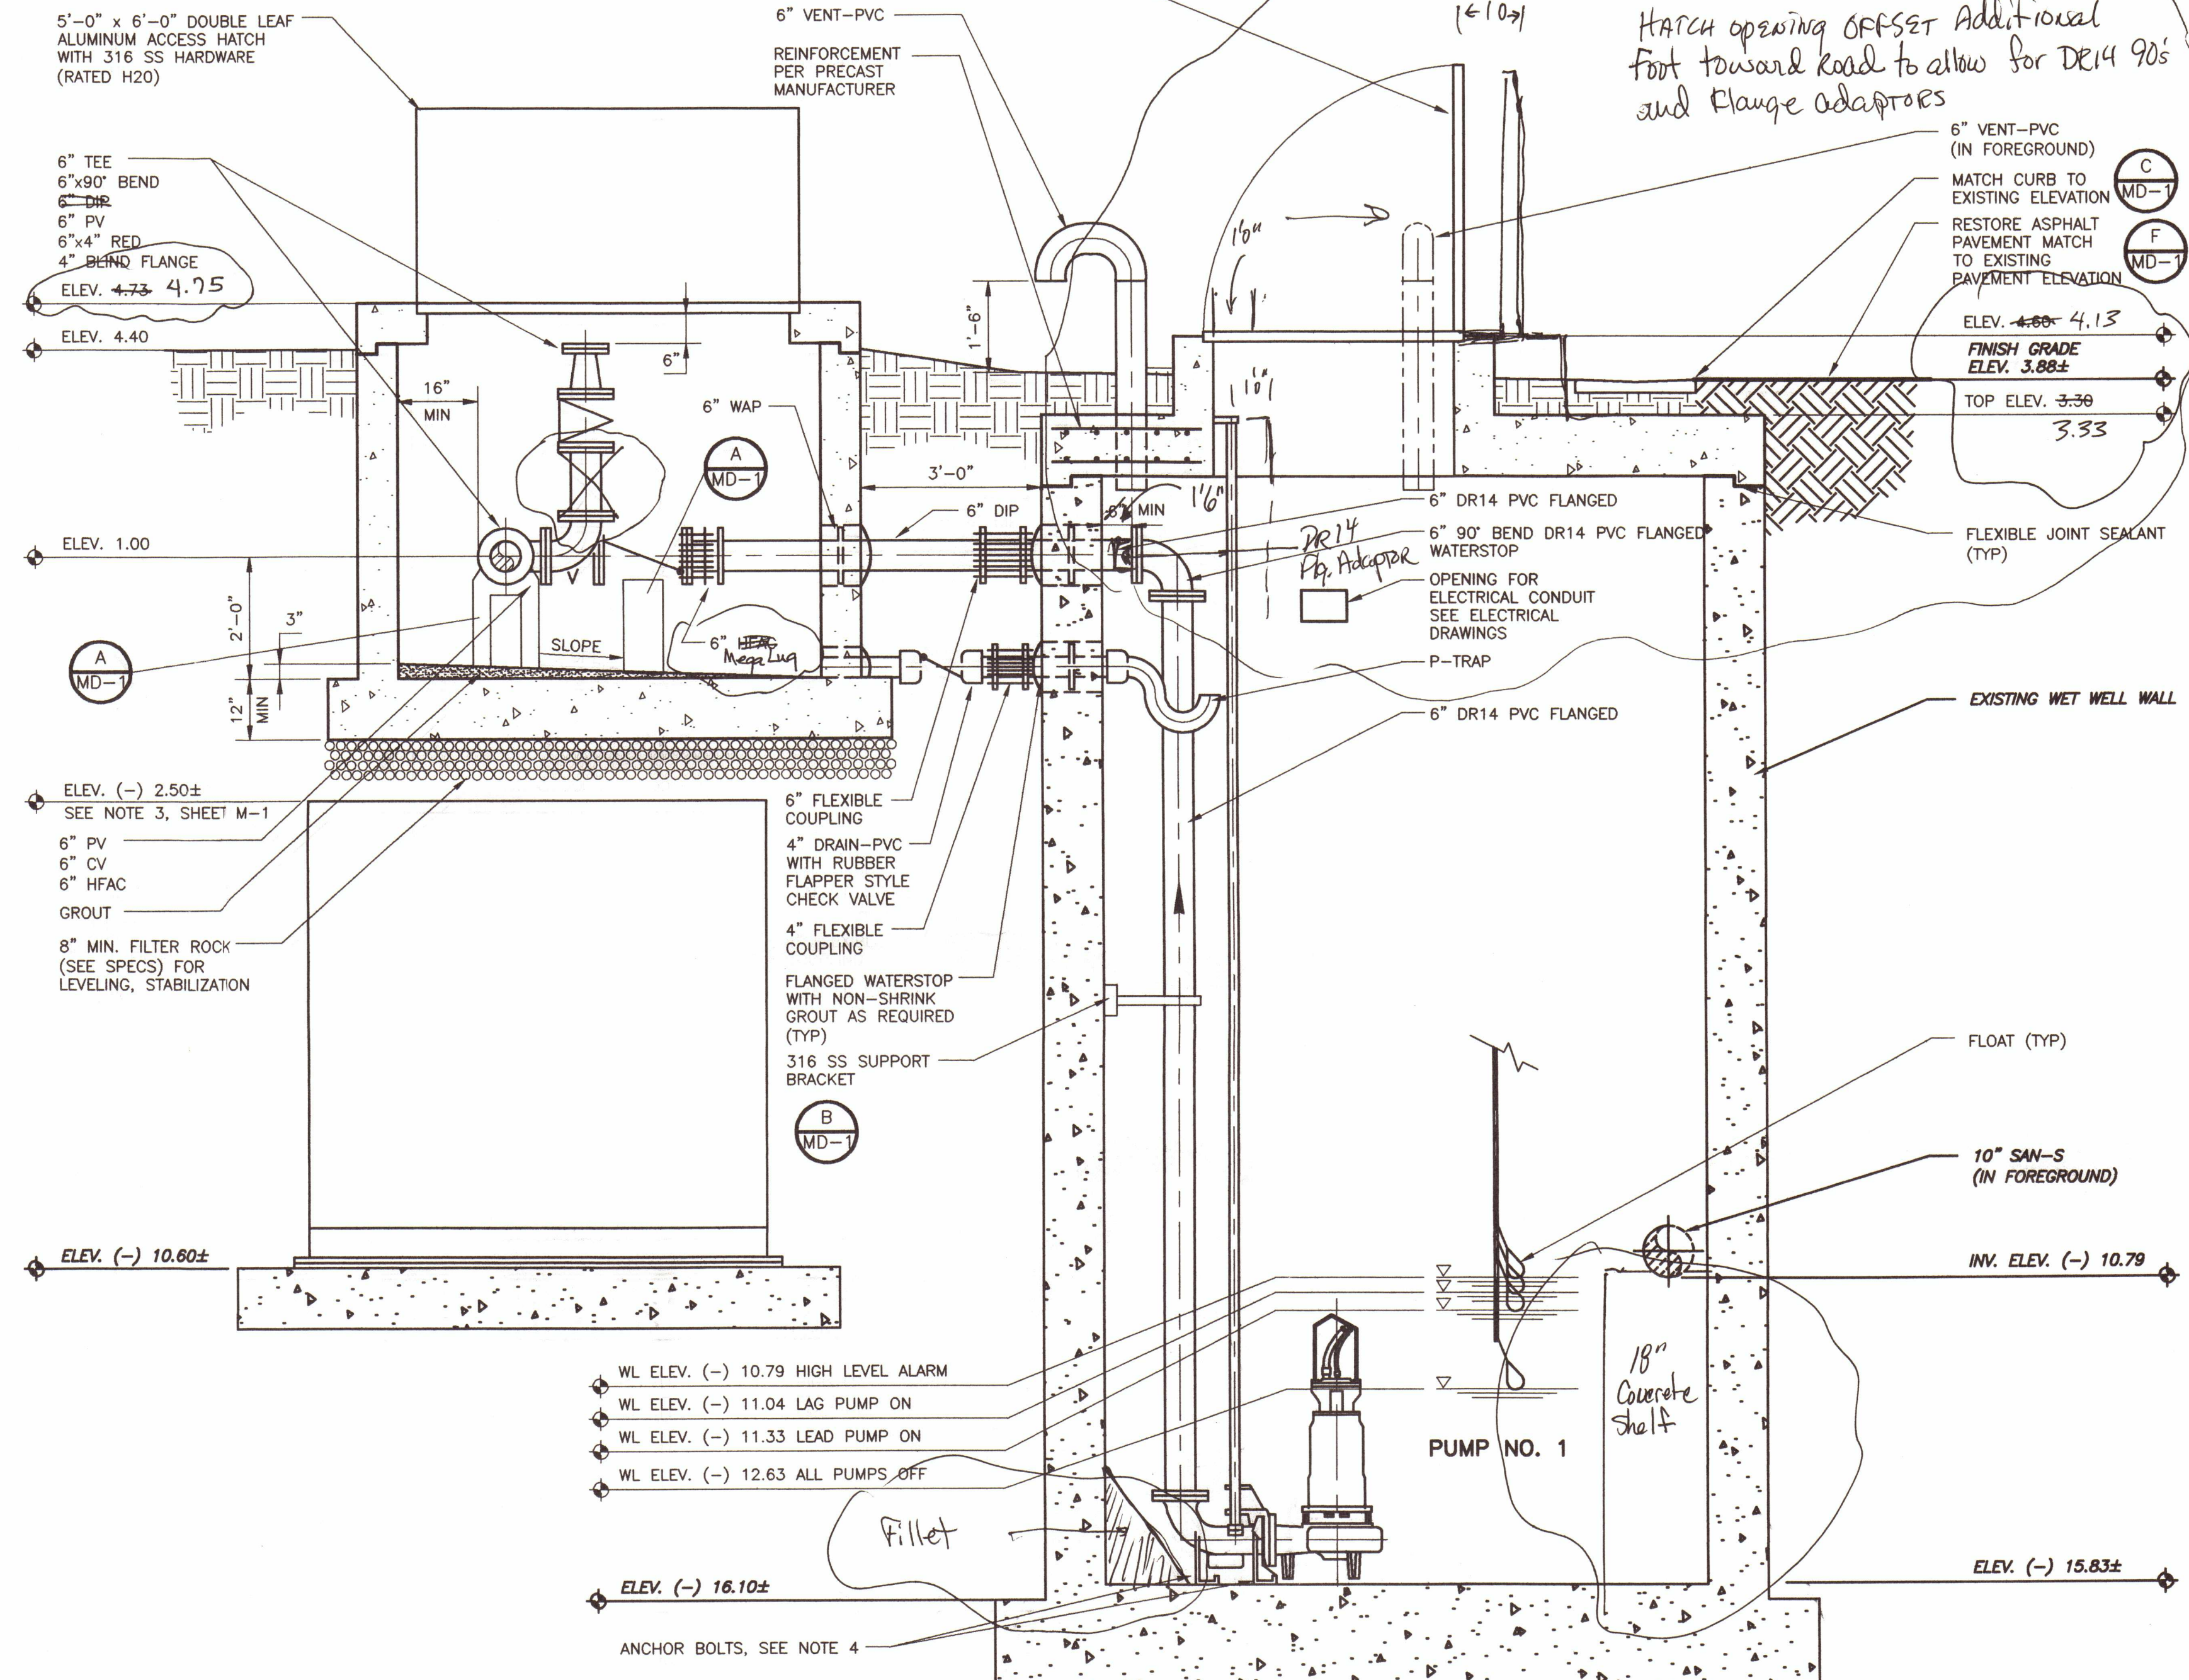

SECTION

1/2" = 1'-0"

1

M-2

TLC Diversified, Inc.
APPROVED
Date 5-7-04 By B1

CONFORMED DRAWINGS
NOVEMBER 2003

ANNE L. ROSS
P.E. NO. 56976
11/18/03

PROJECT NO. 2790-38413
FILE NAME: MLSPM02.dwg

SHEET NO.

M-2

APPLICANT

DESIGNED BY: W. SPRIGGS
DRAWN BY: J. SANCIMINO
SHEET CHK'D BY: A. ROSS
CROSS CHK'D BY: G. CASHON
APPROVED BY: A. ROSS
DATE: AUGUST 2003

CDM Camp Dresser & McKee Inc.
1819 Main Street, Suite 1002
Sarasota, Florida 34236
Tel: 941-363-9696
FL Cert. of Authorization No. 20


TOWN OF LONGBOAT KEY, FLORIDA

LIFT STATION A IMPROVEMENTS


LIFT STATION A MODIFICATION
PLAN AND SECTION

JAN 9 2004

REV. NO.	DATE	DRWN	CHKD	REMARKS
11/03	JAS	WMS		CONFORMED DRAWINGS

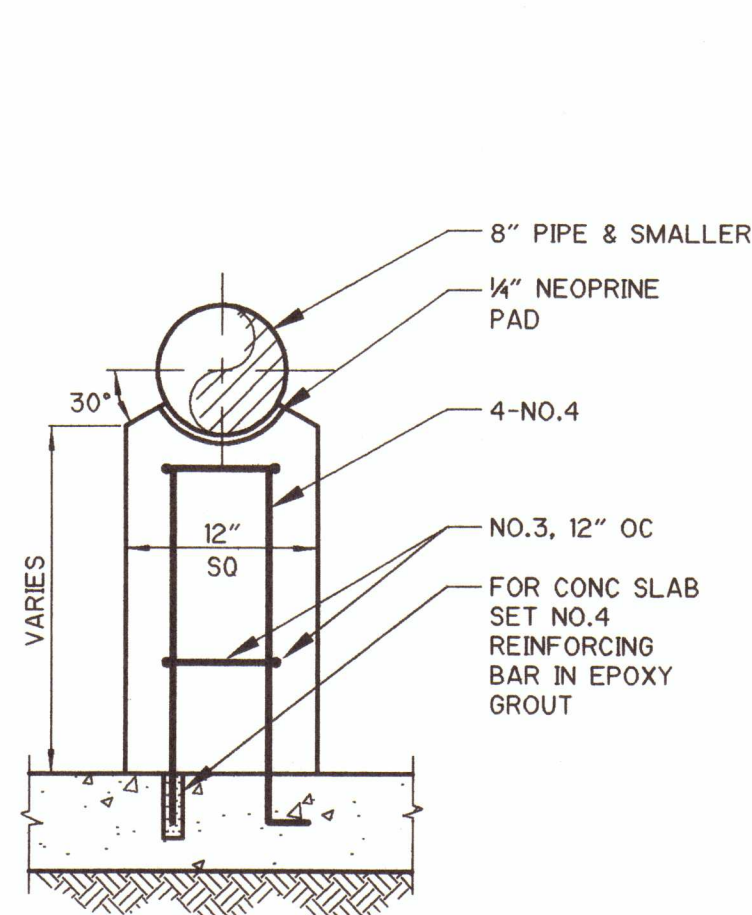


8" PIPE OR SMALLER
DETAIL A
NTS

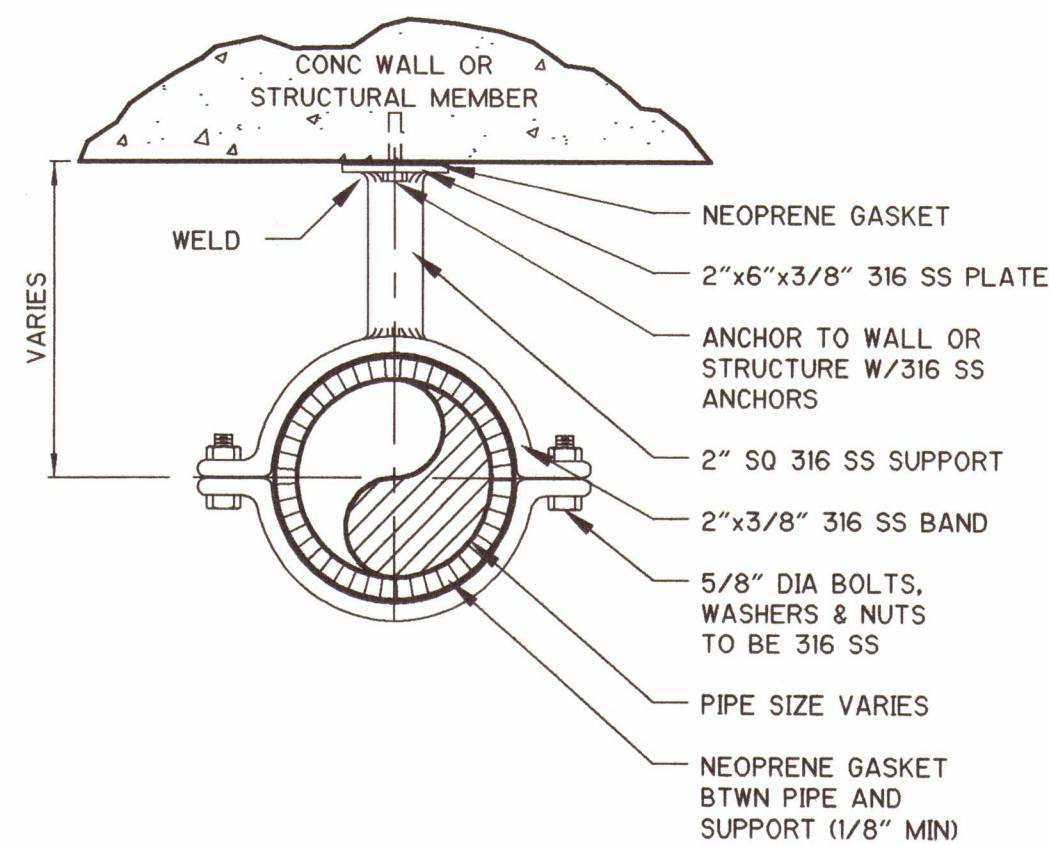



DETAIL B
NTS

NOTES

1. USE WASHERS WITH NUTS AND BOLTS.
2. ALL ANCHORS, FASTENERS, BOLTS, NUTS, WASHERS, SCREWS, ETC. SHALL BE 316 STAINLESS STEEL.
3. DETAILS SHOWN ARE INTENDED TO COVER A WIDE RANGE OF PROJECT SITUATIONS. ALL DETAILS MAY NOT APPLY TO THIS PROJECT.

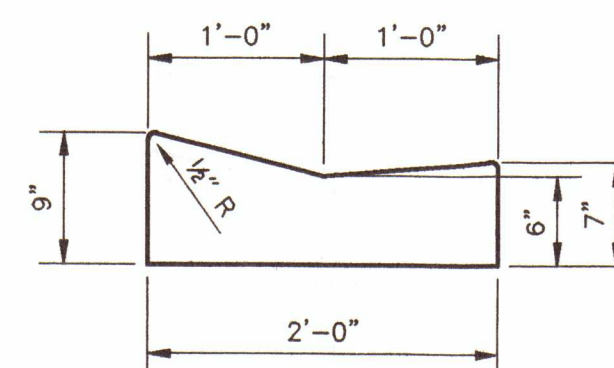

MIAMI CURB AND GUTTER
DETAIL C
NTS

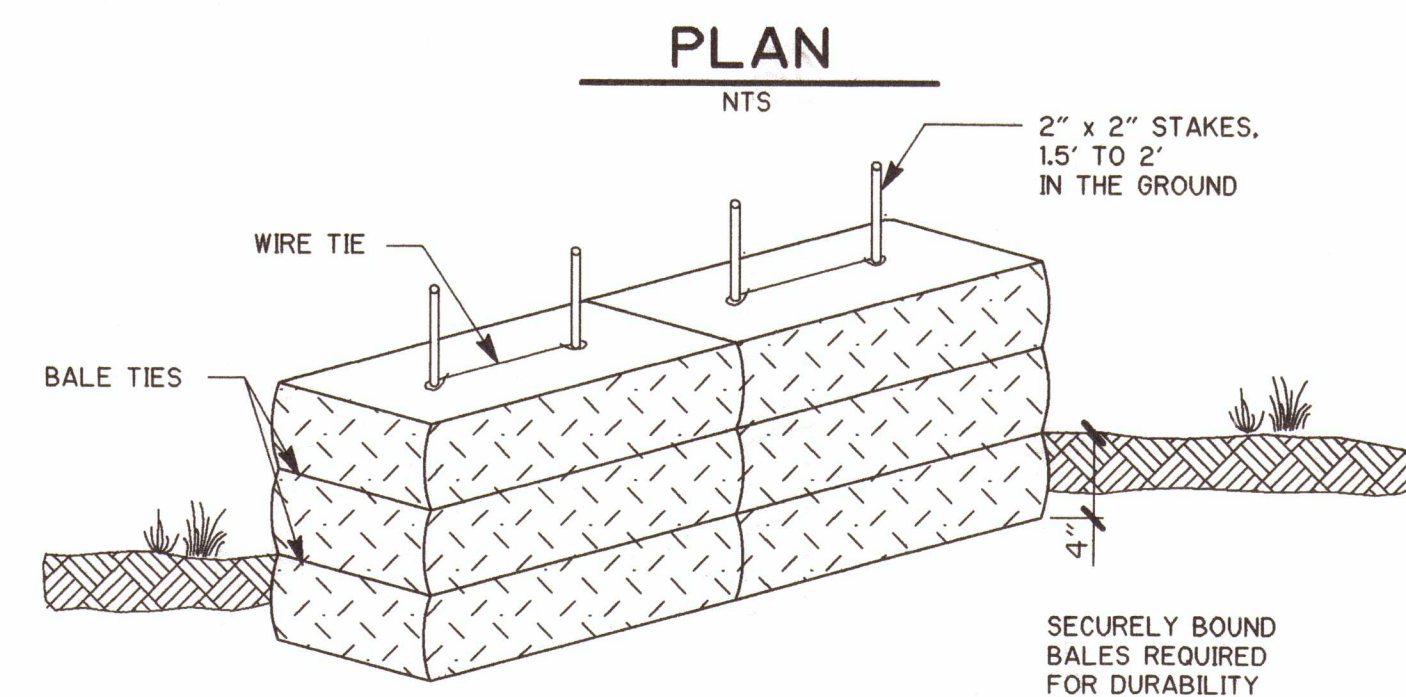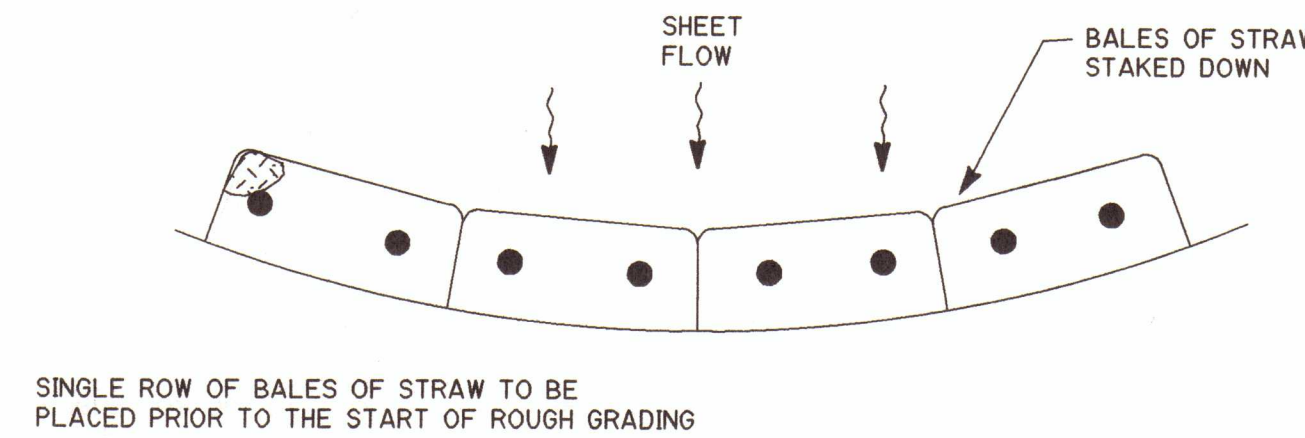


STRAW BALE SEDIMENT BARRIER
DOT INDEX NO. 102

DETAIL D
NTS


NOTE TO CONTRACTOR: EROSION CONTROL MEASURES

REQUIRED EROSION CONTROL MEASURES MUST REMAIN INTACT THROUGHOUT CONSTRUCTION. FAILURE TO INSTALL OR PROPERLY MAINTAIN THESE BARRICADES WILL RESULT IN ENFORCEMENT ACTION WHICH MAY INCLUDE CITATIONS, AS PROVIDED BY ORDINANCE 90-17, AND CHAPTER 400-4 AND 400-40, F.A.C. INITIATION OF CIVIL PENALTY PROCEDURES PURSUANT TO SECTION 373.129 F.A.C., CAN RESULT IN A PENALTY NOT TO EXCEED \$10,000 PER OFFENSE WITH EACH DATE DURING WHICH SUCH VIOLATION OCCURS CONSTITUTING A SEPARATE OFFENSE.

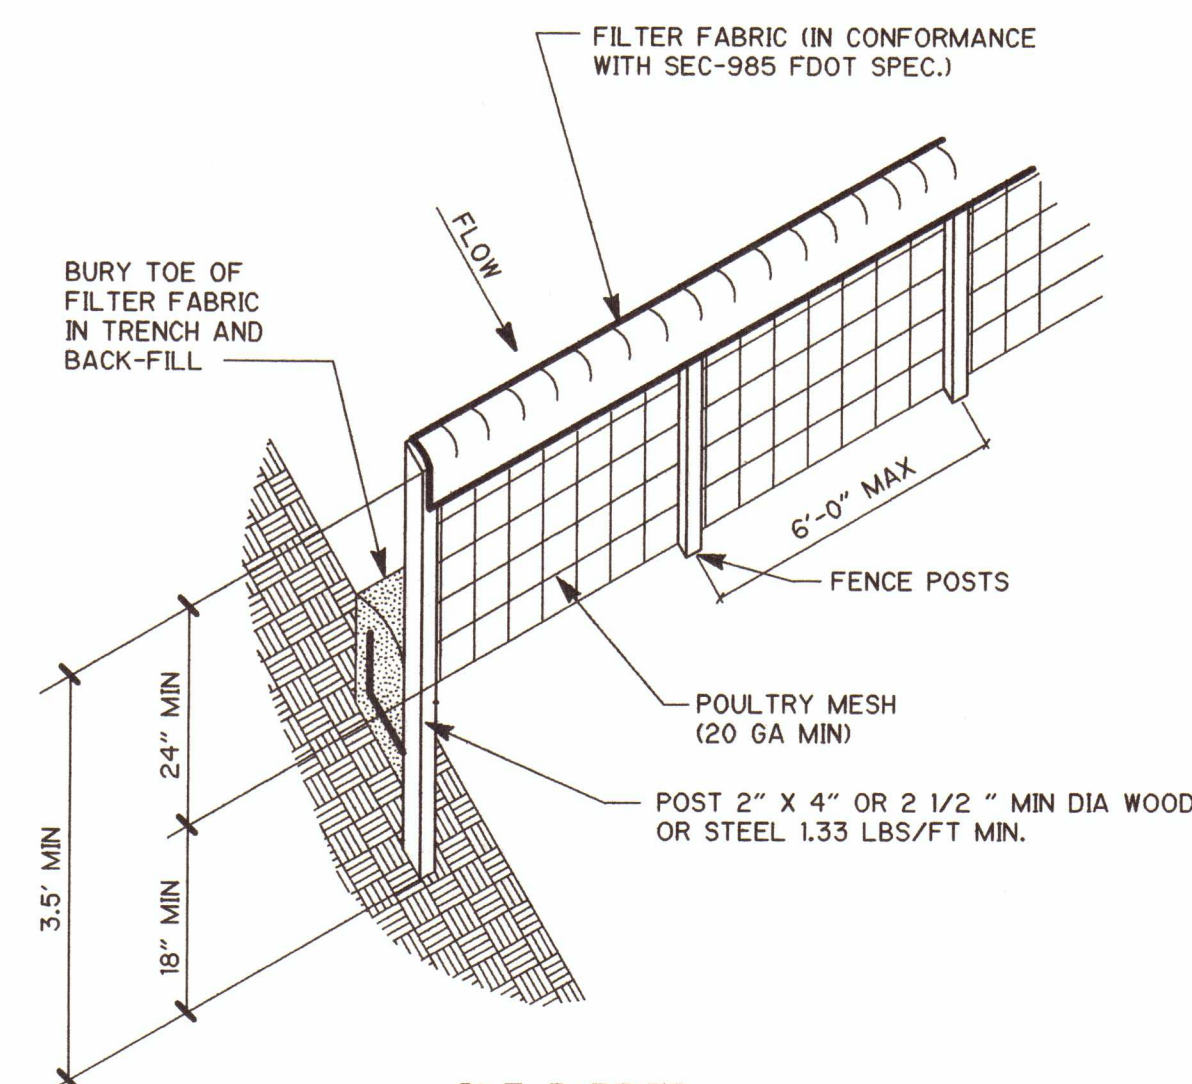

SILT BARRIER
DOT INDEX NO. 102


DETAIL E
NTS

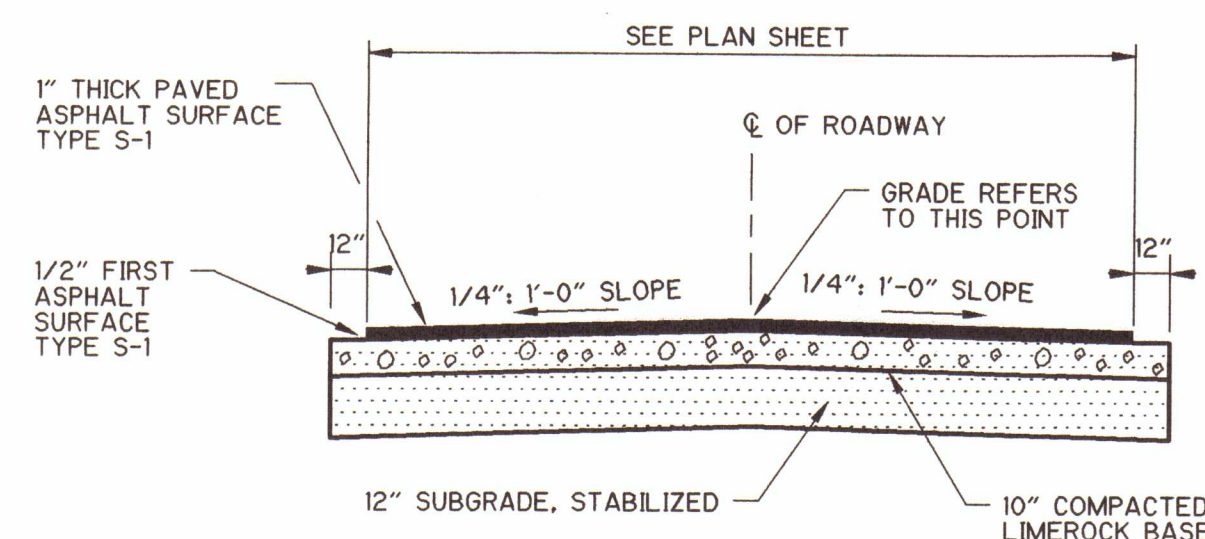

NOTE:
SEE PLAN FOR ROADWAY LOCATIONS. BASE COMPACTION TO A MINIMUM OF 98% MAXIMUM DENSITY AASHTO T-180 METHOD. SUBGRADE STABILIZED PER FDOT STANDARD SPECIFICATIONS FOR ROAD AND BRIDGE CONSTRUCTION.


TYPICAL ROADWAY DETAIL

DETAIL F
NTS

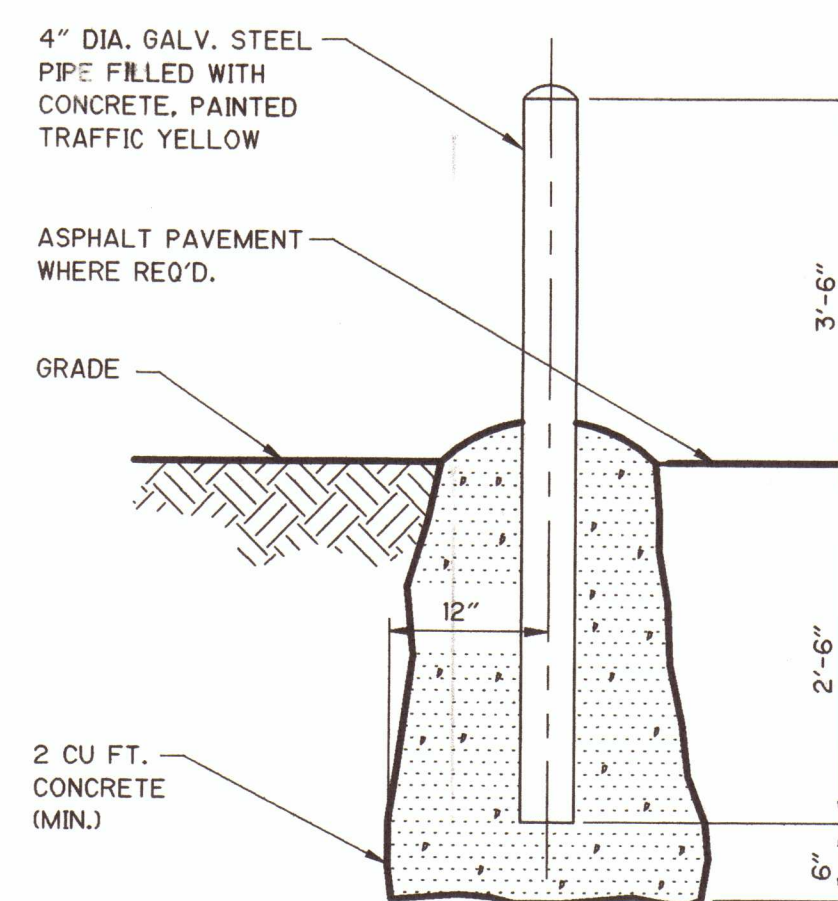


GUARD POST

DETAIL G
NTS

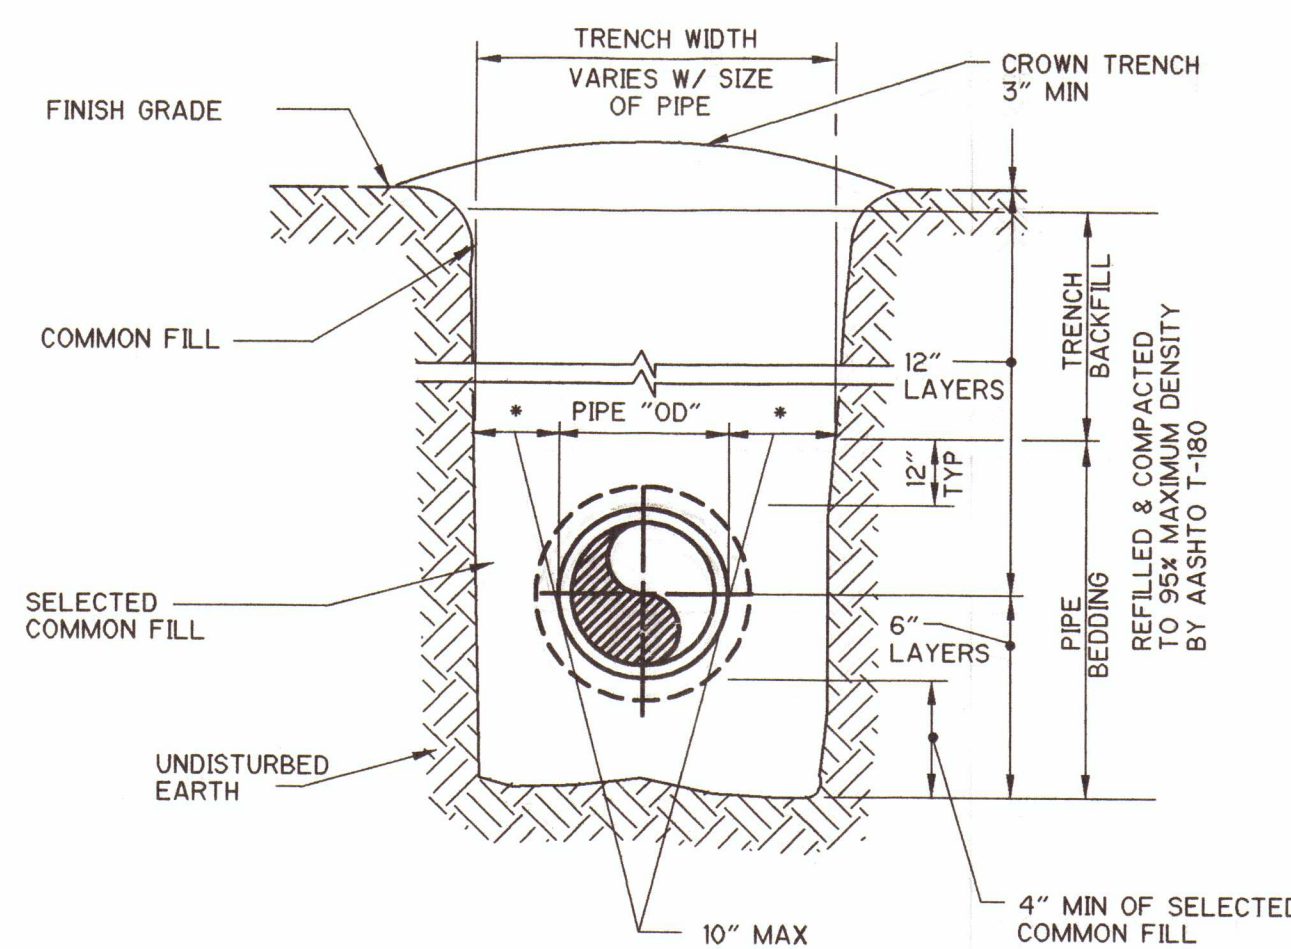

UNIMPROVED SURFACE
TYPE A-1 PIPE BEDDING

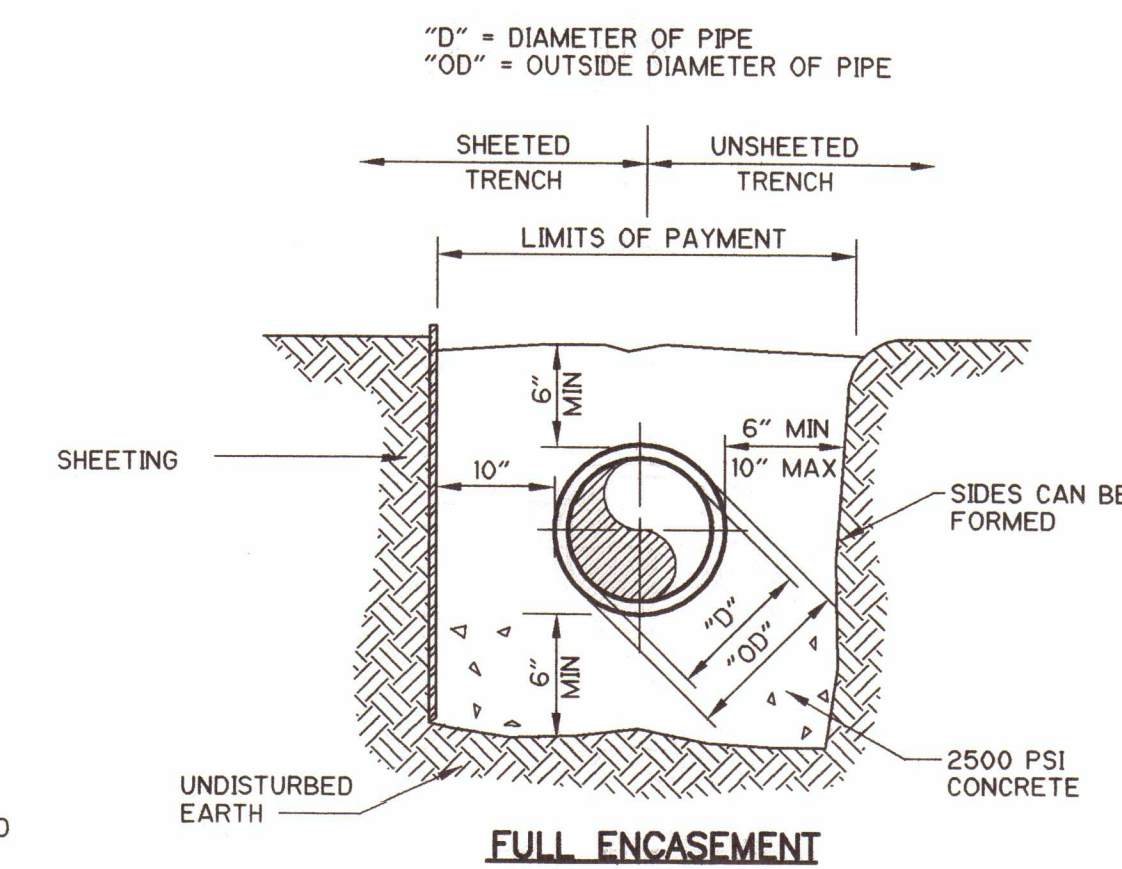

FULL ENCASEMENT

CONFORMED DRAWINGS
NOVEMBER 2003

ANNE L. ROSS
P.E. NO. 56976
11/19/03

PROJECT NO. 2790-38413
FILE NAME: MSD01MD1.dwg

SHEET NO.
MD-1

APPLICANT

REV. NO.	DATE	DRWN	CHKD	REMARKS
11/03	JAS	WMS		CONFORMED DRAWINGS


DESIGNED BY: W. SPRIGGS
DRAWN BY: J. SANCIMINO
SHEET CHK'D BY: A. ROSS
CROSS CHK'D BY: G. CASHON
APPROVED BY: A. ROSS
DATE: AUGUST 2003

CDM Camp Dresser & McKee Inc.
1819 Main Street, Suite 1002
Sarasota, Florida 34236
Tel: 941-353-8696
FL Cert. of Authorization No. 20

TOWN OF LONGBOAT KEY, FLORIDA

LIFT STATION A IMPROVEMENTS

MISCELLANEOUS DETAILS JAN 9 2004

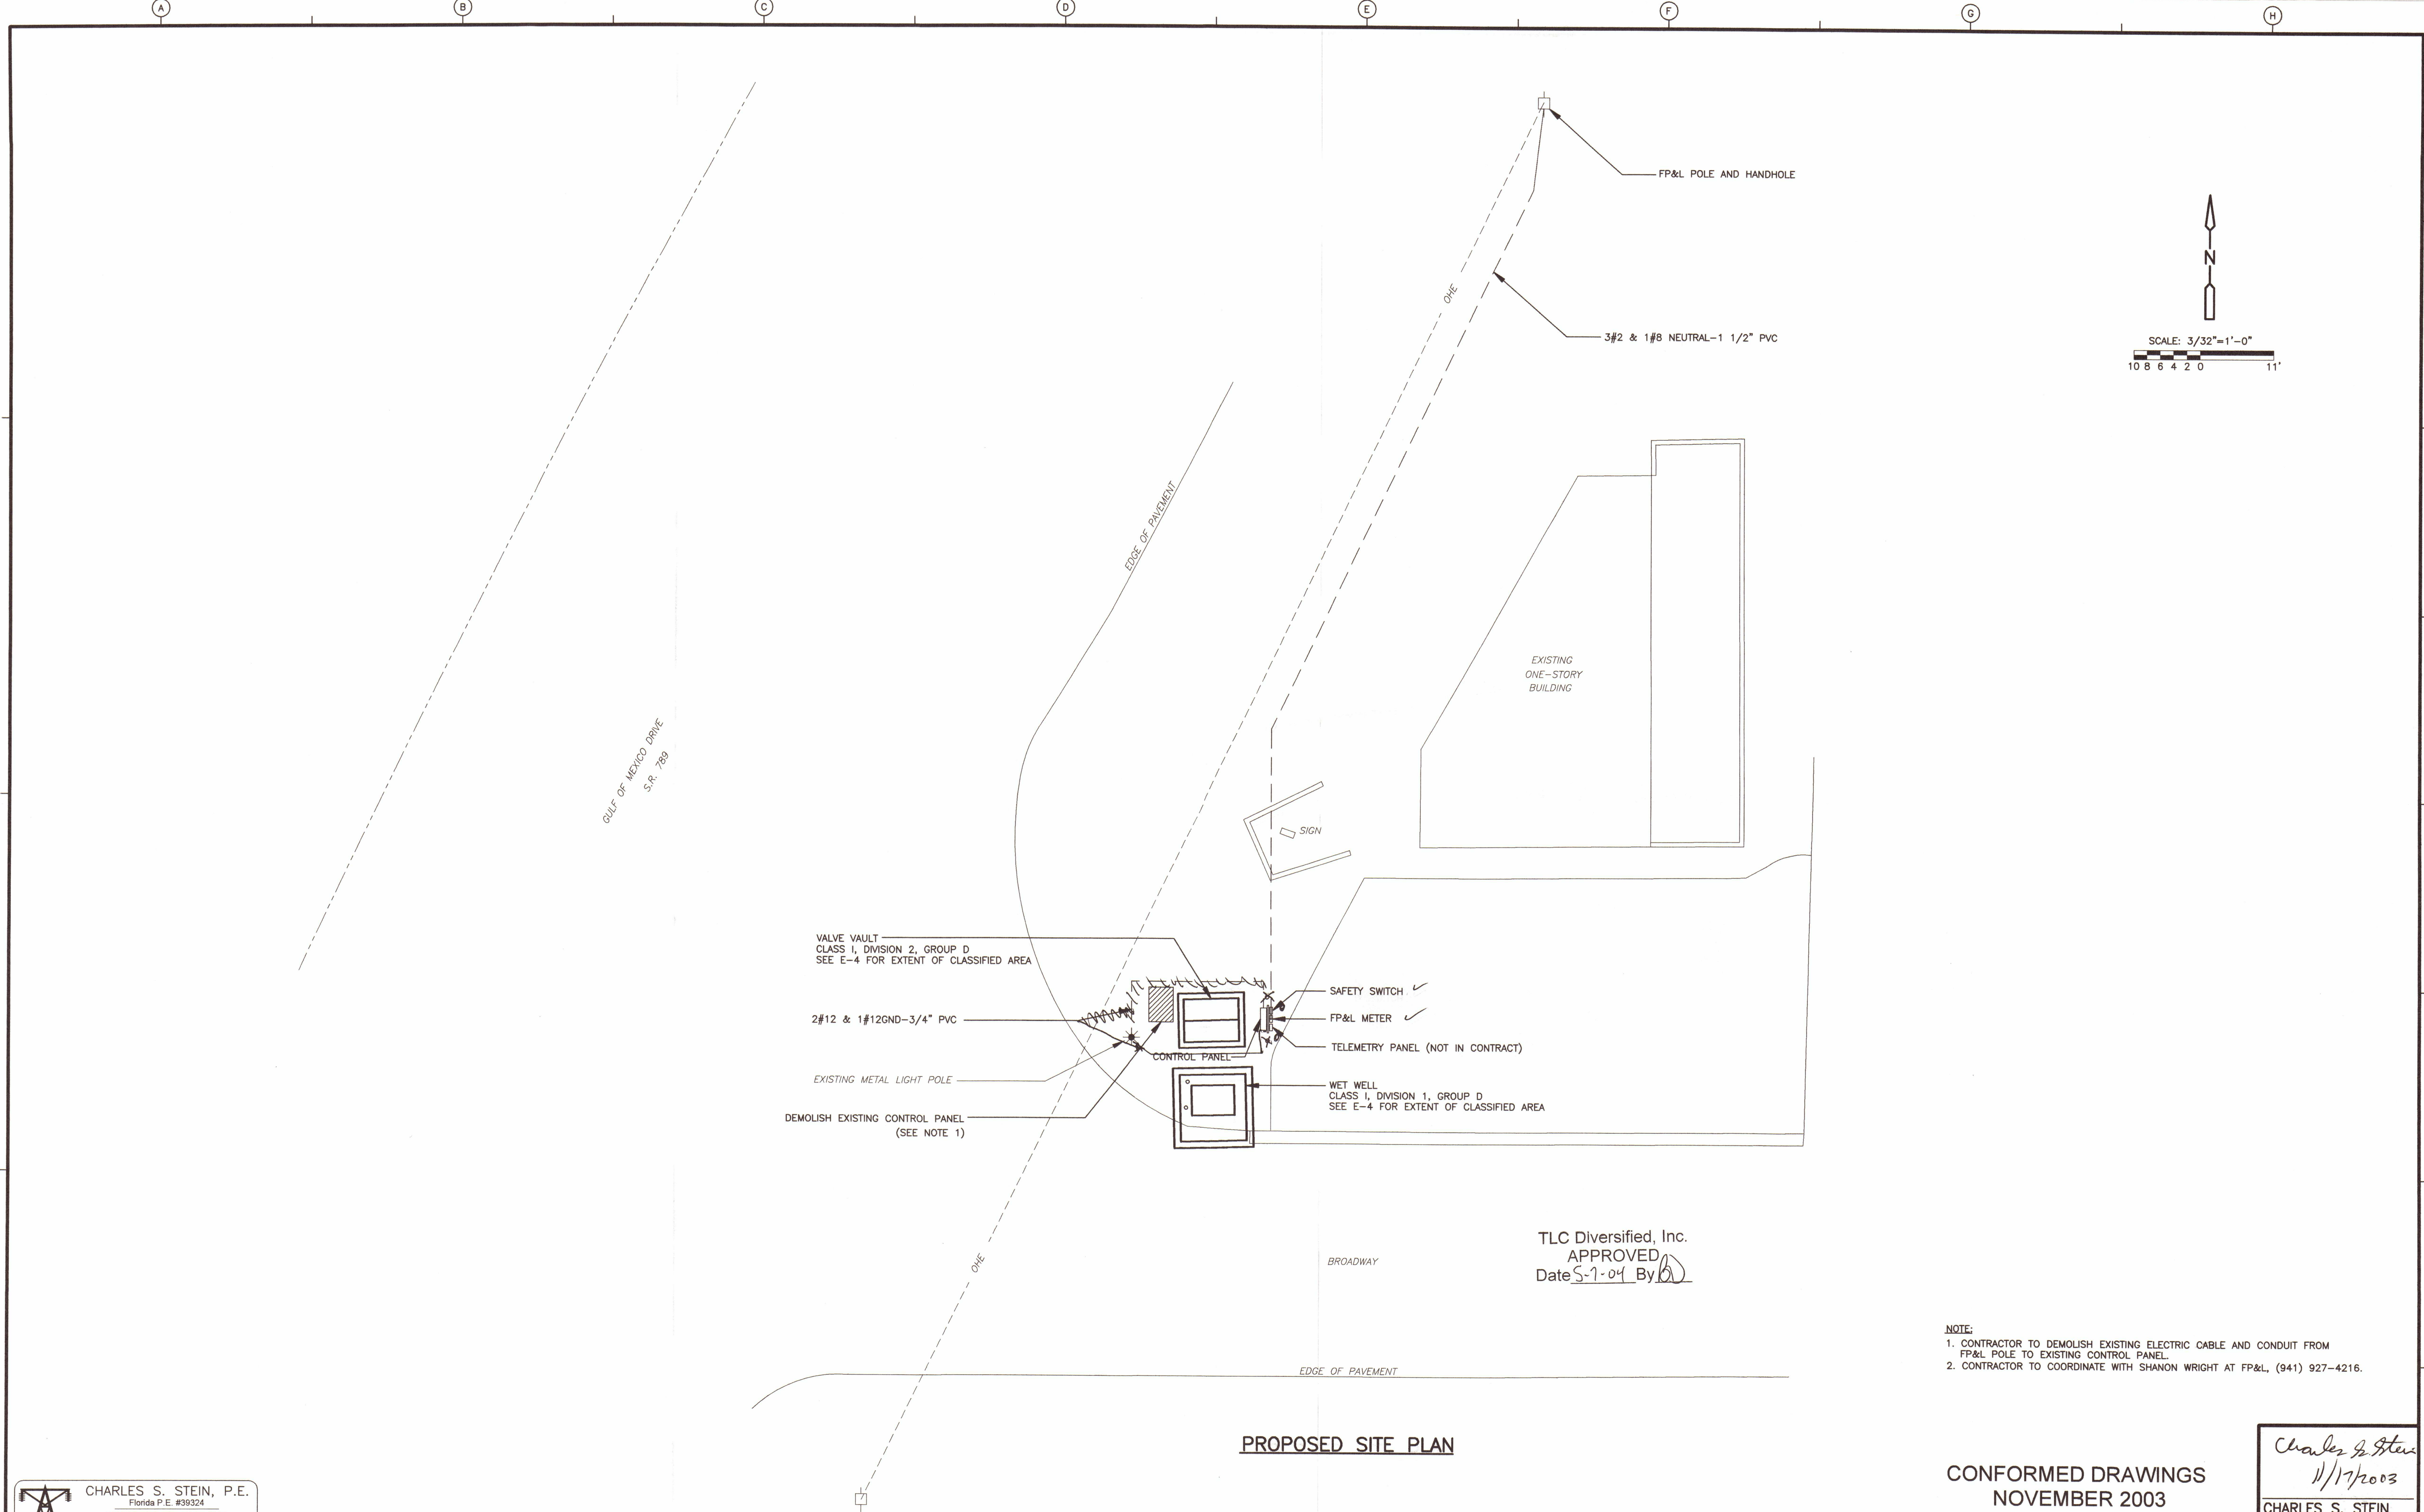

CHARLES S. STEIN, P.E.
Florida P.E. #39324
23055 Post Gardens Way, #133
Boca Raton, Florida 33433
(561) 392-5340 • SteinCS@aol.com
www.gladespower.com

REV. NO.	DATE	DRWN	CHKD	REMARKS

DESIGNED BY: C. STEIN
DRAWN BY: C. STEIN
SHEET CHK'D BY: P. LEFAVE
CROSS CHK'D BY: A. ROSS
APPROVED BY: C. STEIN
DATE: AUGUST 2003

CDM Camp Dresser & McKee Inc.
consulting
engineering
construction
operations
1819 Main Street, Suite 1002
Sarasota, Florida 34236
Tel: 941-353-0695
FL Cert. of Authorization No. 20

TOWN OF LONGBOAT KEY, FLORIDA
LIFT STATION A IMPROVEMENTS

ELECTRICAL SITE PLAN
JAN 9 2004

Charles S. Stein
11/17/2003
CHARLES S. STEIN
P.E. NO. 39324
PROJECT NO. 2790-38413
FILE NAME: E01.dwg
SHEET NO.
E-1
APPLICANT



CONFORMED DRAWINGS
NOVEMBER 2003

NOTE:
1. CONTRACTOR TO DEMOLISH EXISTING ELECTRIC CABLE AND CONDUIT FROM
FP&L POLE TO EXISTING CONTROL PANEL.
2. CONTRACTOR TO COORDINATE WITH SHANON WRIGHT AT FP&L, (941) 927-4216.

TLC Diversified, Inc.
APPROVED
Date 5-7-04 By [Signature]

9/5/31/5 11/03/03 144343

P:\2790\38413\Conformed\Mech\ M.SDPW01

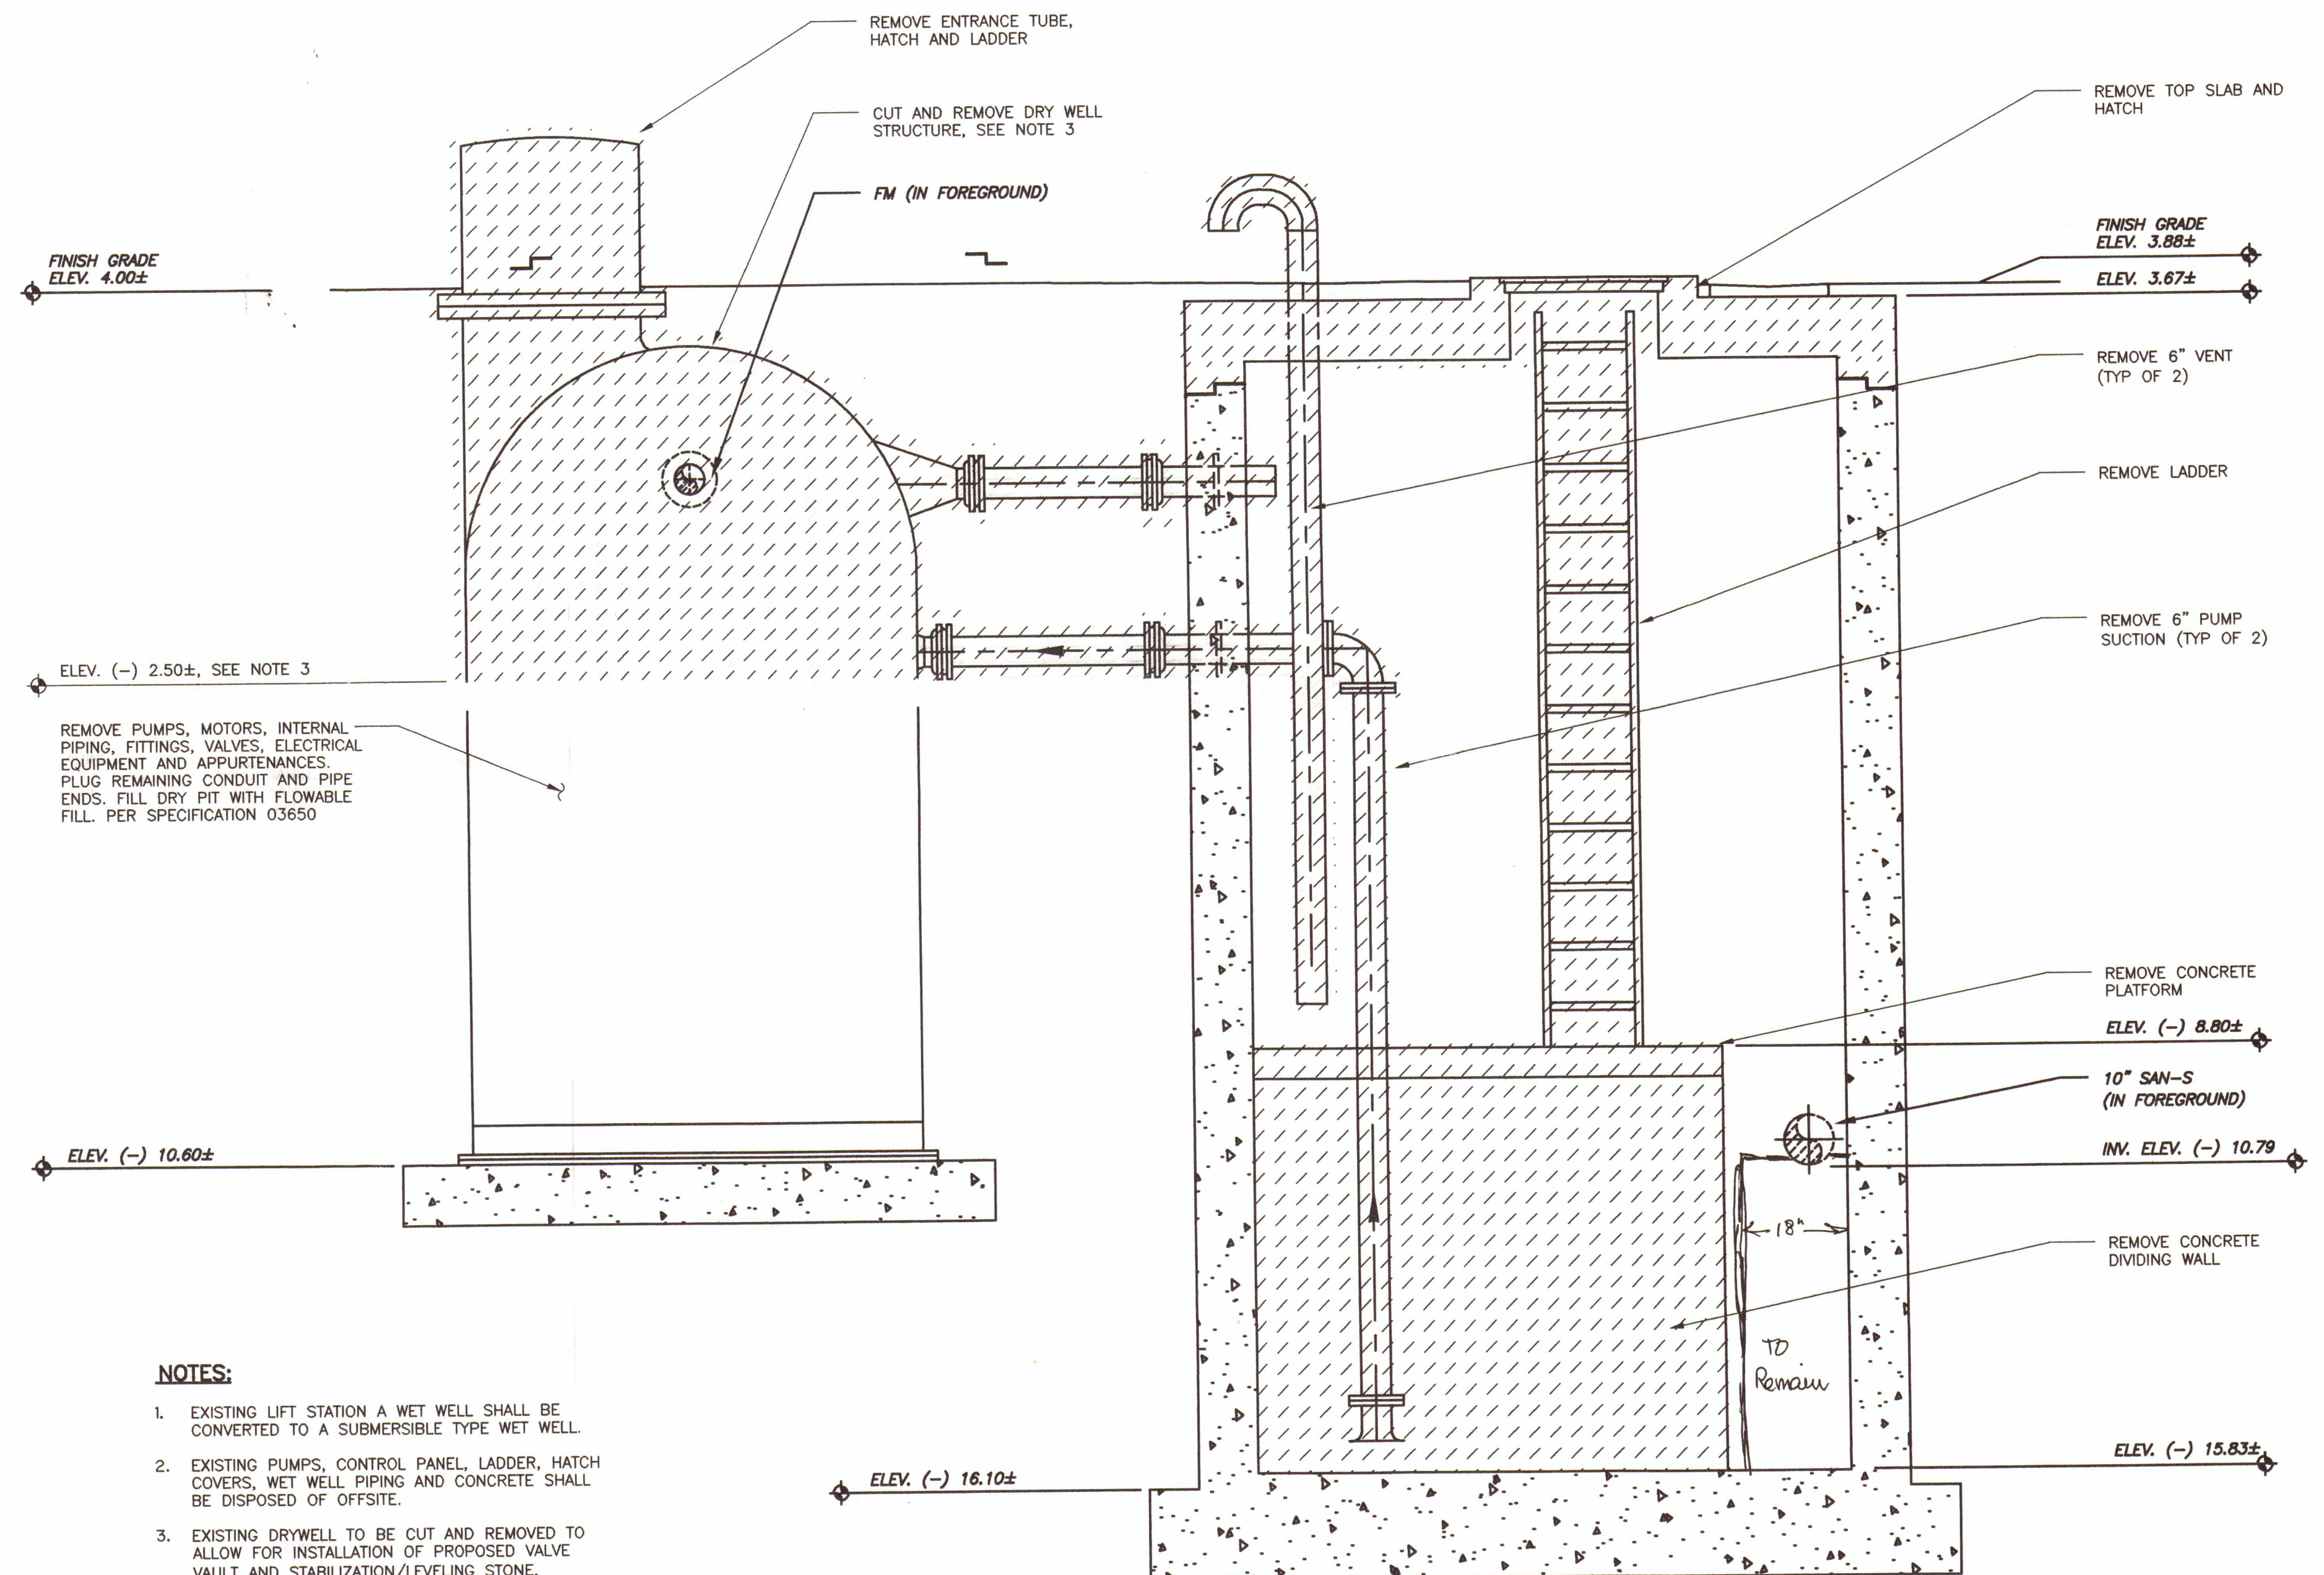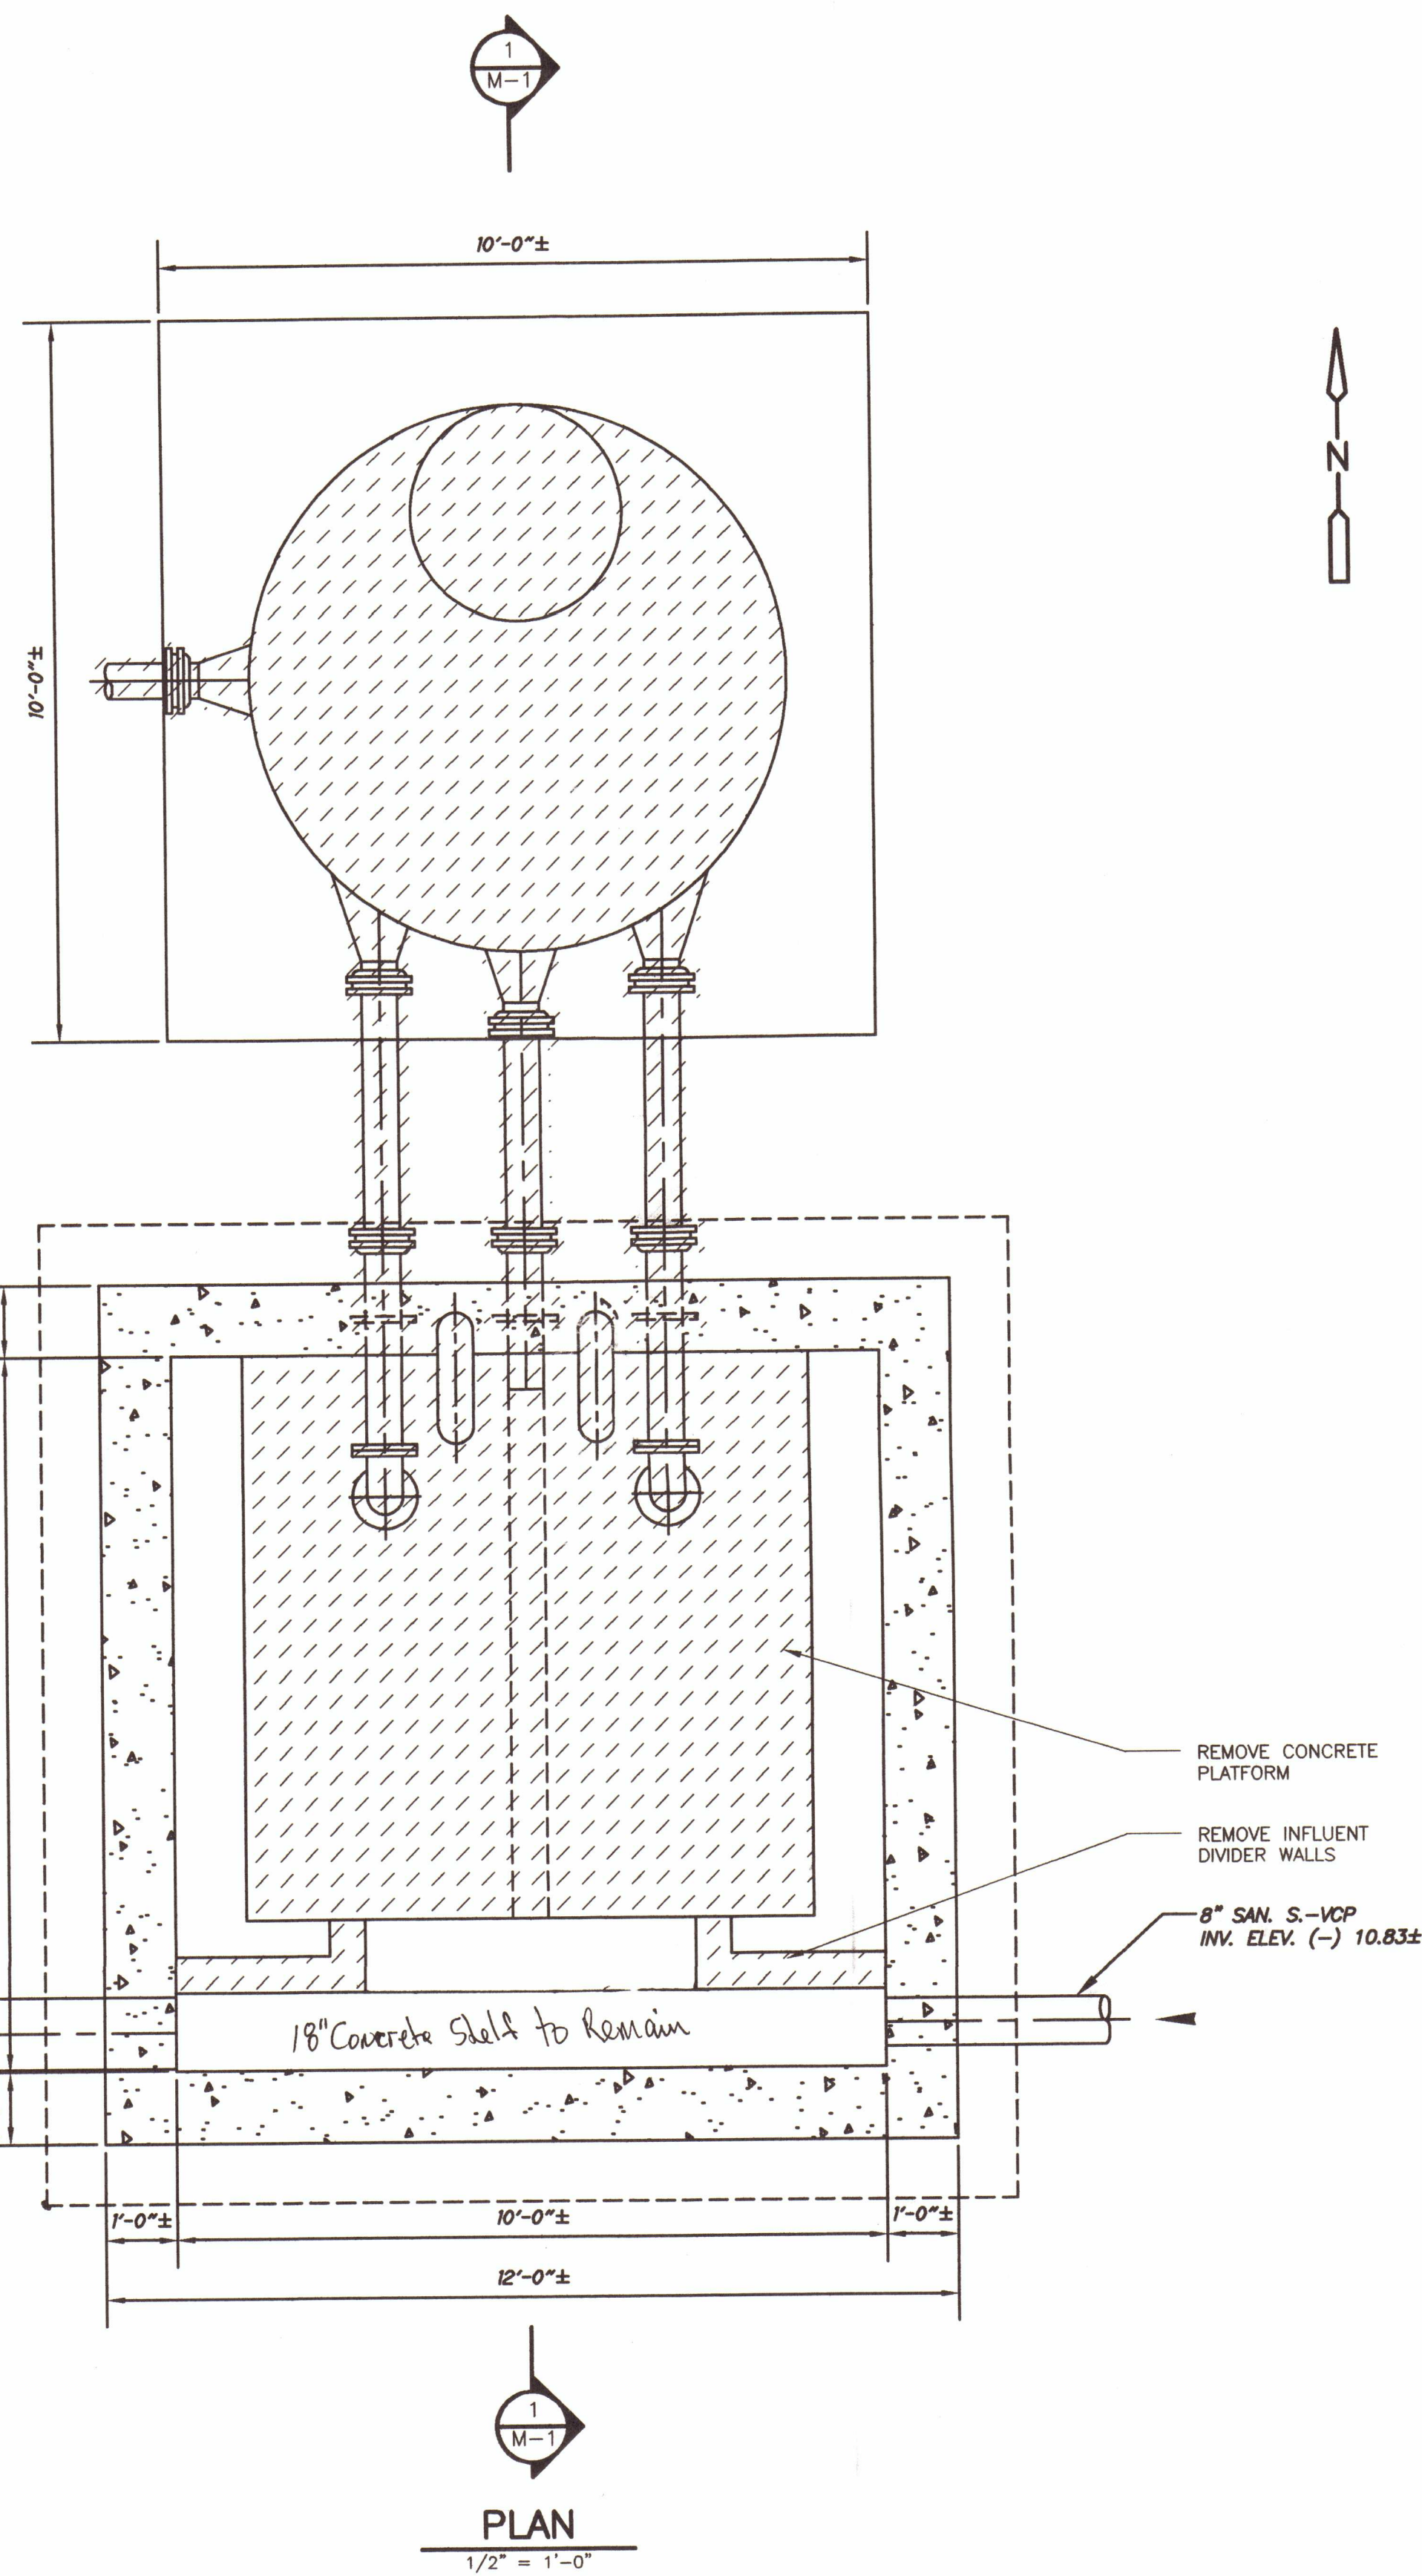

NOTES:

- EXISTING LIFT STATION A WET WELL SHALL BE CONVERTED TO A SUBMERSIBLE TYPE WET WELL.
- EXISTING PUMPS, CONTROL PANEL, LADDER, HATCH COVERS, WET WELL PIPING AND CONCRETE SHALL BE DISPOSED OF OFFSITE.
- EXISTING DRYWELL TO BE CUT AND REMOVED TO ALLOW FOR INSTALLATION OF PROPOSED VALVE VAULT AND STABILIZATION/LEVELING STONE. COORDINATE DEPTH OF REMOVAL WITH PRECAST MANUFACTURER. FILL REMAINING DRY WELL WITH CONCRETE/FLOWABLE FILL.
- DIMENSIONS, LOCATION AND ELEVATIONS OF THE DRY WELL ARE PRESENTED AS ON TOWN OF LONGBOAT KEY WASTEWATER SYSTEM DRAWINGS, 1975. CONTRACTOR TO FIELD VERIFY.
- DIMENSIONS FOR THE WET WELL ARE PRESENTED AS ON TOWN OF LONGBOAT KEY WASTEWATER SYSTEM DRAWINGS, 1975. CONTRACTOR TO FIELD VERIFY.
- EXISTING PIPING PENETRATIONS SHALL BE FILLED WITH NON-SHRINK GROUT PER SPECIFICATIONS.
- EXISTING DRYWELL IS PRE-FABRICATED FACTORY BUILT. CONSTRUCTION MATERIAL IS FIBERGLASS.
- CONTRACTOR TO RELOCATE SUITABLE SURPLUS SOIL MATERIAL TO OWNER PROPERTY AT 280 GULF OF MEXICO DRIVE.

CONFORMED DRAWINGS
NOVEMBER 2003

ANNE L. ROSS
P.E. NO. 56976
11/18/03

PROJECT NO. 2790-38413
FILE NAME: M.SDPW01.dwg

SHEET NO.

M-1

APPLICANT

CDM Camp Dresser & McKee Inc.
1819 Main Street, Suite 1002
Sarasota, Florida 34236
Tel. 941-363-9696
FL Cert. of Authorization No. 20

TOWN OF LONGBOAT KEY, FLORIDA




LIFT STATION A IMPROVEMENTS

LIFT STATION A DEMOLITION
PLAN AND SECTION

JAN 9 2004

REV. NO.	DATE	DRWN	CHKD	REMARKS
1	11/03	JAS	WMS	CONFORMED DRAWINGS

DESIGNED BY: W. SPRIGGS
DRAWN BY: J. SANCIMINO
SHEET CHK'D BY: A. ROSS
CROSS CHK'D BY: G. CASHON
APPROVED BY: A. ROSS
DATE: AUGUST 2003

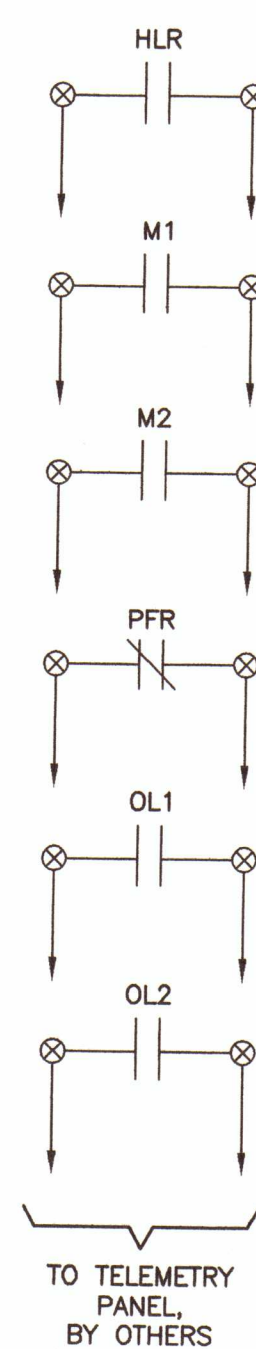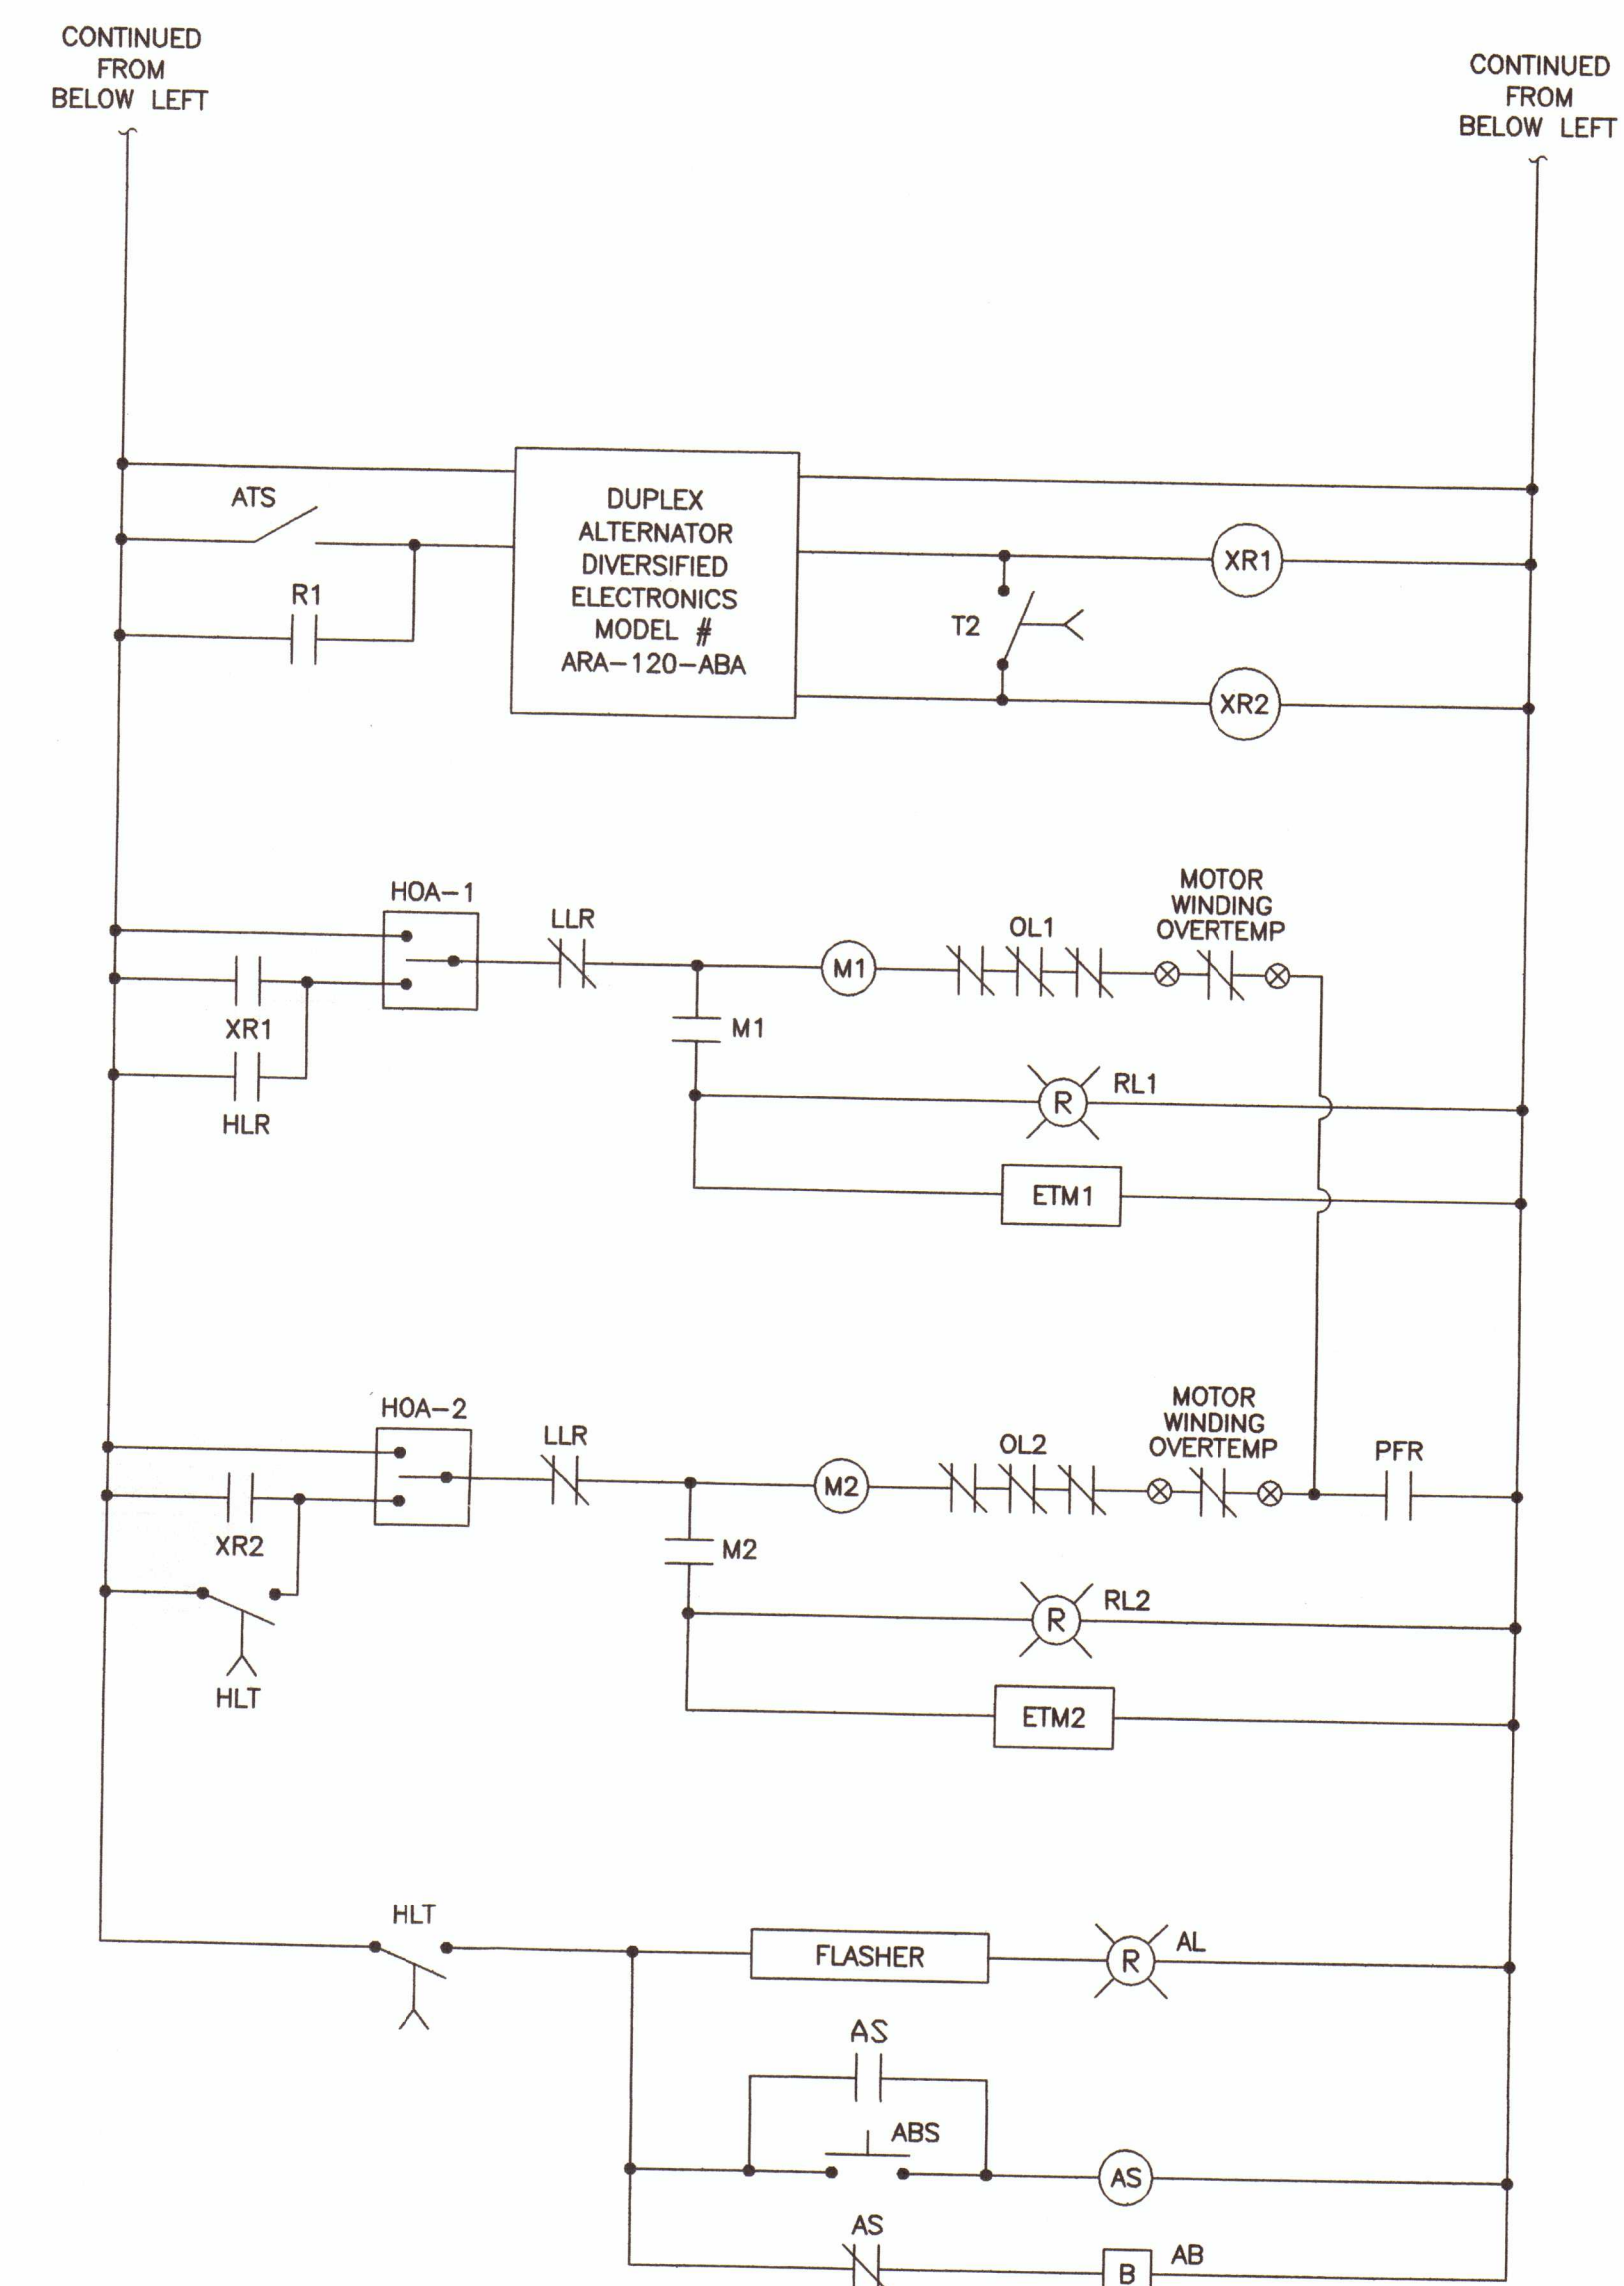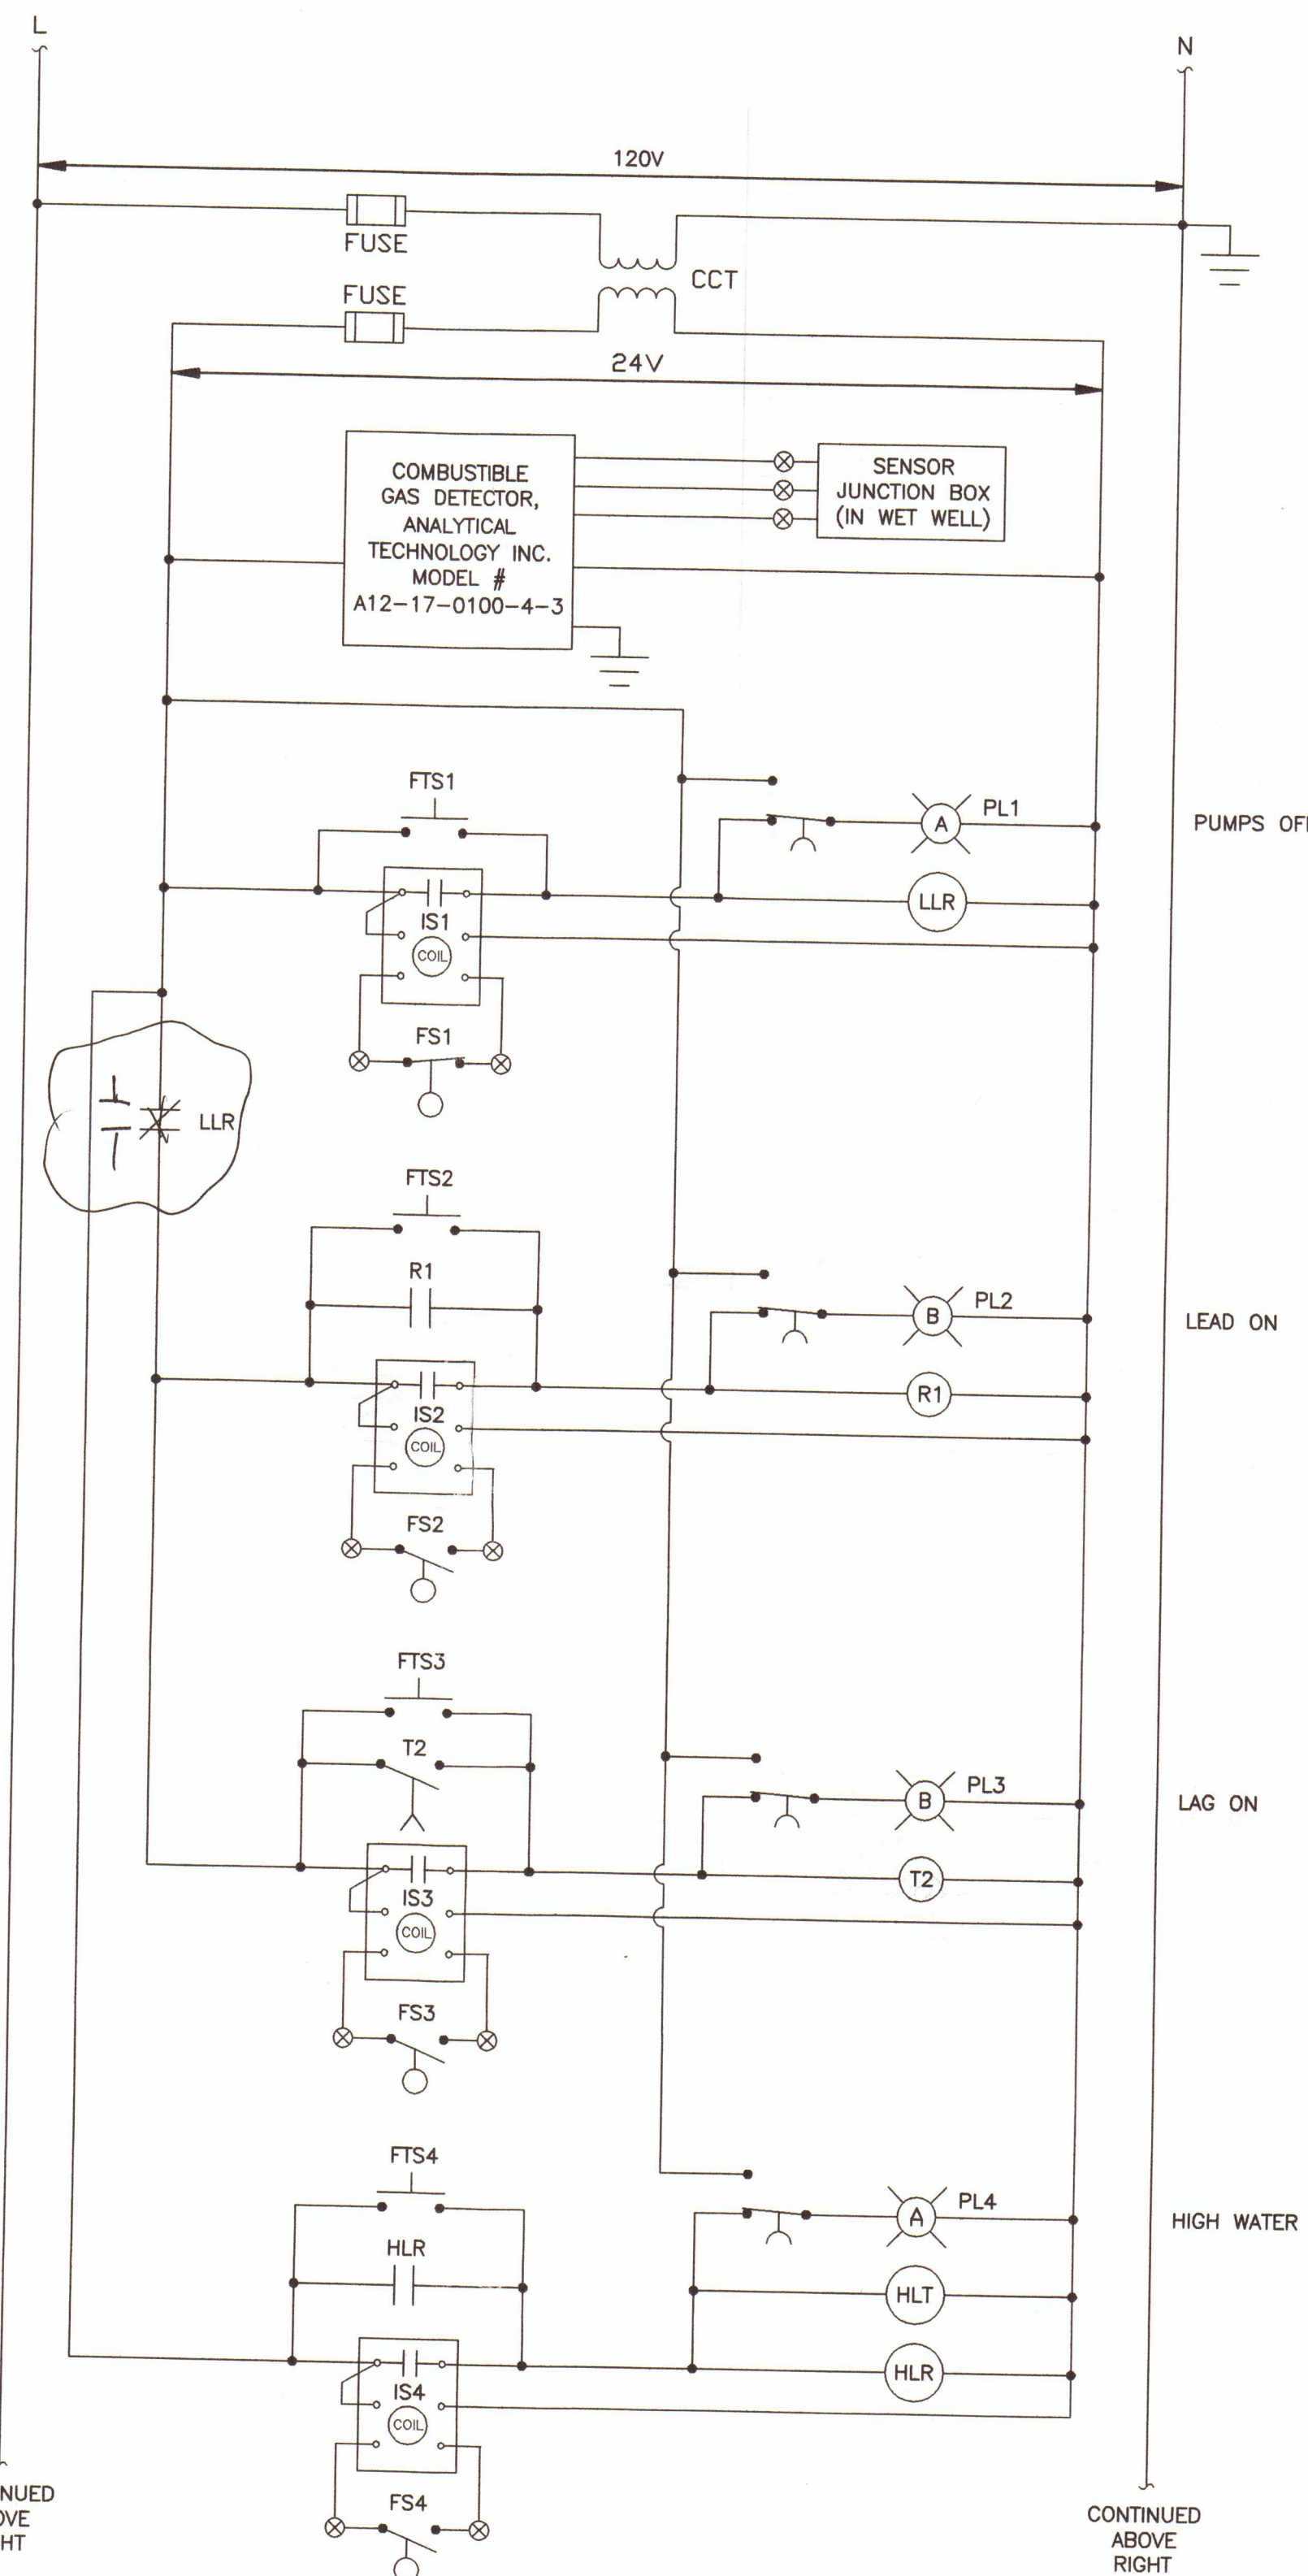

CONTROL CIRCUIT DIAGRAM

AB - ALARM BELL (120V)
ABS - ALARM BELL SILENCER
AL - ALARM LIGHT (120V)
AL1 - ALTERNATOR
AS - ALARM RELAY (120V)
ATS - ALTERNATOR TEST SWITCH
CB1 - PUMP NO. 1 CIRCUIT BREAKER
CB2 - PUMP NO. 2 CIRCUIT BREAKER
CB3 - CPT PRIMARY SIDE CIRCUIT BREAKER
CB4 - CPT SECONDARY SIDE CIRCUIT BREAKER
CB5 - 120V CONTROL CIRCUIT BREAKER
CB6 - DUPLEX RECEPTACLE CIRCUIT BREAKER
CB7 - INSTRUMENT PANEL CIRCUIT BREAKER
CB8 - LIGHT PO1 CIRCUIT BREAKER
CCT - CONTROL POWER TRANSFORMER (120V-24V)
CPT - CONTROL POWER TRANSFORMER (230V-120V)
ETM - ELAPSED TIME METER (120V)
FB - FUSE BLOCK
FL - FLASHER (110V SOLID STATE)
FS - FLOAT SWITCH
FS1 - FLOAT TEST SWITCH
GCB - GENERATOR CIRCUIT BREAKER (INTERLOCKED WITH MCB)
GDFR - GROUND FAULT DUPLEX RECEPTACLE
GR - GENERATOR RECEPTACLE
GRD - GROUND
HLR - HIGH LEVEL RELAY (24V)
HLT - HIGH LEVEL TIME DELAY RELAY (24V)
HOA - HAND-OFF-AUTO SWITCH
IS - INTRINSICALLY SAFE RELAYS
LA - LIGHTNING ARRESTOR
LLR - LOW LEVEL RELAY (24V)
M1 - PUMP NO. 1 MOTOR STARTER
M2 - PUMP NO. 2 MOTOR STARTER
MCB - MAIN CIRCUIT BREAKER
NB - NEUTRAL BLOCK
OL1 - PUMP NO. 1 SOLID STATE OVERLOAD UNIT
OL2 - PUMP NO. 2 SOLID STATE OVERLOAD UNIT
PDB - POWER DISTRIBUTION BLOCK
PFR - PHASE FAILURE RELAY (230V)
PL - LEVEL INDICATORS (PUSH-TO-TEST) (24V)
R - PUMP RUN INDICATORS (PUSH-TO-TEST) (120V)
RL - LEAD PUMP CALL RELAY (24V)
SS - STAINLESS STEEL
TB - TERMINAL BLOCKS
T2 - LAG PUMP CALL TIME DELAY RELAY (24V)
XR1 - PUMP NO. 1 CALL RELAY (120V)
XR2 - PUMPS NO. 2 CALL RELAY (120V)

CONTINUED
ABOVE
RIGHT

CONTINUED
ABOVE
RIGHT

~~Don't~~ ~~on~~ ~~Stewart~~
Refer to O's M's

PROJECT NO. 2790-38413
FILE NAME: E02.dwg

SHEET NO.

E-2

APPLICANT



CHARLES S. STEIN, P.E.
 Florida P.E. #39324
 23055 Post Gardens Way, #133
 Boca Raton, Florida 33433
 (561) 392-5346 - SteinCS@aol.com
www.gladespowers.com

DESIGNED BY: C. STEIN
DRAWN BY: C. STEIN
SHEET CHK'D BY: P. LEFAVE
CROSS CHK'D BY: A. ROSS
APPROVED BY: C. STEIN
DATE: AUGUST 2003

CDM Camp Dresser & McKee Inc.
consulting
engineering
construction
operations
1819 Main Street, Suite 1002
Sarasota, Florida 34236
Tel: 941-363-9696
FL Cert. of Authorization No. 20

TOWN OF LONGBOAT KEY, FLORIDA


LIFT STATION A IMPROVEMENTS

POWER AND CONTROL DIAGRAMS JAN 9 2004


REV. NO.	DATE	DRWN	CHKD	REMARKS
-------------	------	------	------	---------

FRONT VIEW ABBREVIATIONS

AB - ALARM BELL (120V)
 ABS - ALARM BELL SILENCER
 AL - ALARM LIGHT (120V)
 ALT - ALTERNATOR
 AS - ALARM RELAY (120V)
 ATS - ALTERNATOR TEST SWITCH
 CB1 - PUMP NO. 1 CIRCUIT BREAKER
 CB2 - PUMP NO. 2 CIRCUIT BREAKER
 CB3 - CPT PRIMARY SIDE CIRCUIT BREAKER
 CB4 - CPT SECONDARY SIDE CIRCUIT BREAKER
 CB5 - 120V CONTROL CIRCUIT BREAKER
 CB6 - DUPLEX RECEPTACLE CIRCUIT BREAKER
 CB7 - INSTRUMENT PANEL CIRCUIT BREAKER
 CB8 - LIGHT POLE CIRCUIT BREAKER
 CCT - CONTROL POWER TRANSFORMER (120V-24V)
 CGD - COMBUSTIBLE GAS DETECTOR
 CPT - CONTROL POWER TRANSFORMER (230V-120V)
 ETM - ELAPSED TIME METER (120V)
 FB - FUSE BLOCK
 FL - FLASHER (110V SOLID STATE)
 FS - FLOAT SWITCH
 FTS - FLOAT TEST SWITCH
 GCB - GENERATOR CIRCUIT BREAKER (INTERLOCKED WITH MCB)
 GFDR - GROUND FAULT DUPLEX RECEPTACLE
 GR - GENERATOR RECEPTACLE
 GRD - GROUND LUGS
 HLR - HIGH LEVEL RELAY (24V)
 HLT - HIGH LEVEL TIME DELAY RELAY (24V)
 HOA - HAND-OFF-AUTO SWITCH
 IS - INTRINSICALLY SAFE RELAYS
 LA - LIGHTNING ARRESTOR
 LLR - LOW LEVEL RELAY (24V)
 M1 - PUMP NO. 1 MOTOR STARTER
 M2 - PUMP NO. 2 MOTOR STARTER
 MCB - MAIN CIRCUIT BREAKER
 NB - NEUTRAL BLOCK
 OL1 - PUMP NO. 1 SOLID STATE OVERLOAD UNIT
 OL2 - PUMP NO. 2 SOLID STATE OVERLOAD UNIT
 PDB - POWER DISTRIBUTION BLOCK
 PFR - PHASE FAILURE RELAY (230V)
 PL - LEVEL INDICATORS (PUSH-TO-TEST) (24V)
 RL - PUMP RUN INDICATORS (PUSH-TO-TEST) (120V)
 R1 - LEAD PUMP CALL RELAY (24V)
 SS - STAINLESS STEEL
 TB - TERMINAL BLOCKS
 T2 - LAG PUMP CALL TIME DELAY RELAY (24V)
 XR1 - PUMP NO. 1 CALL RELAY (120V)
 XR2 - PUMPS NO. 2 CALL RELAY (120V)

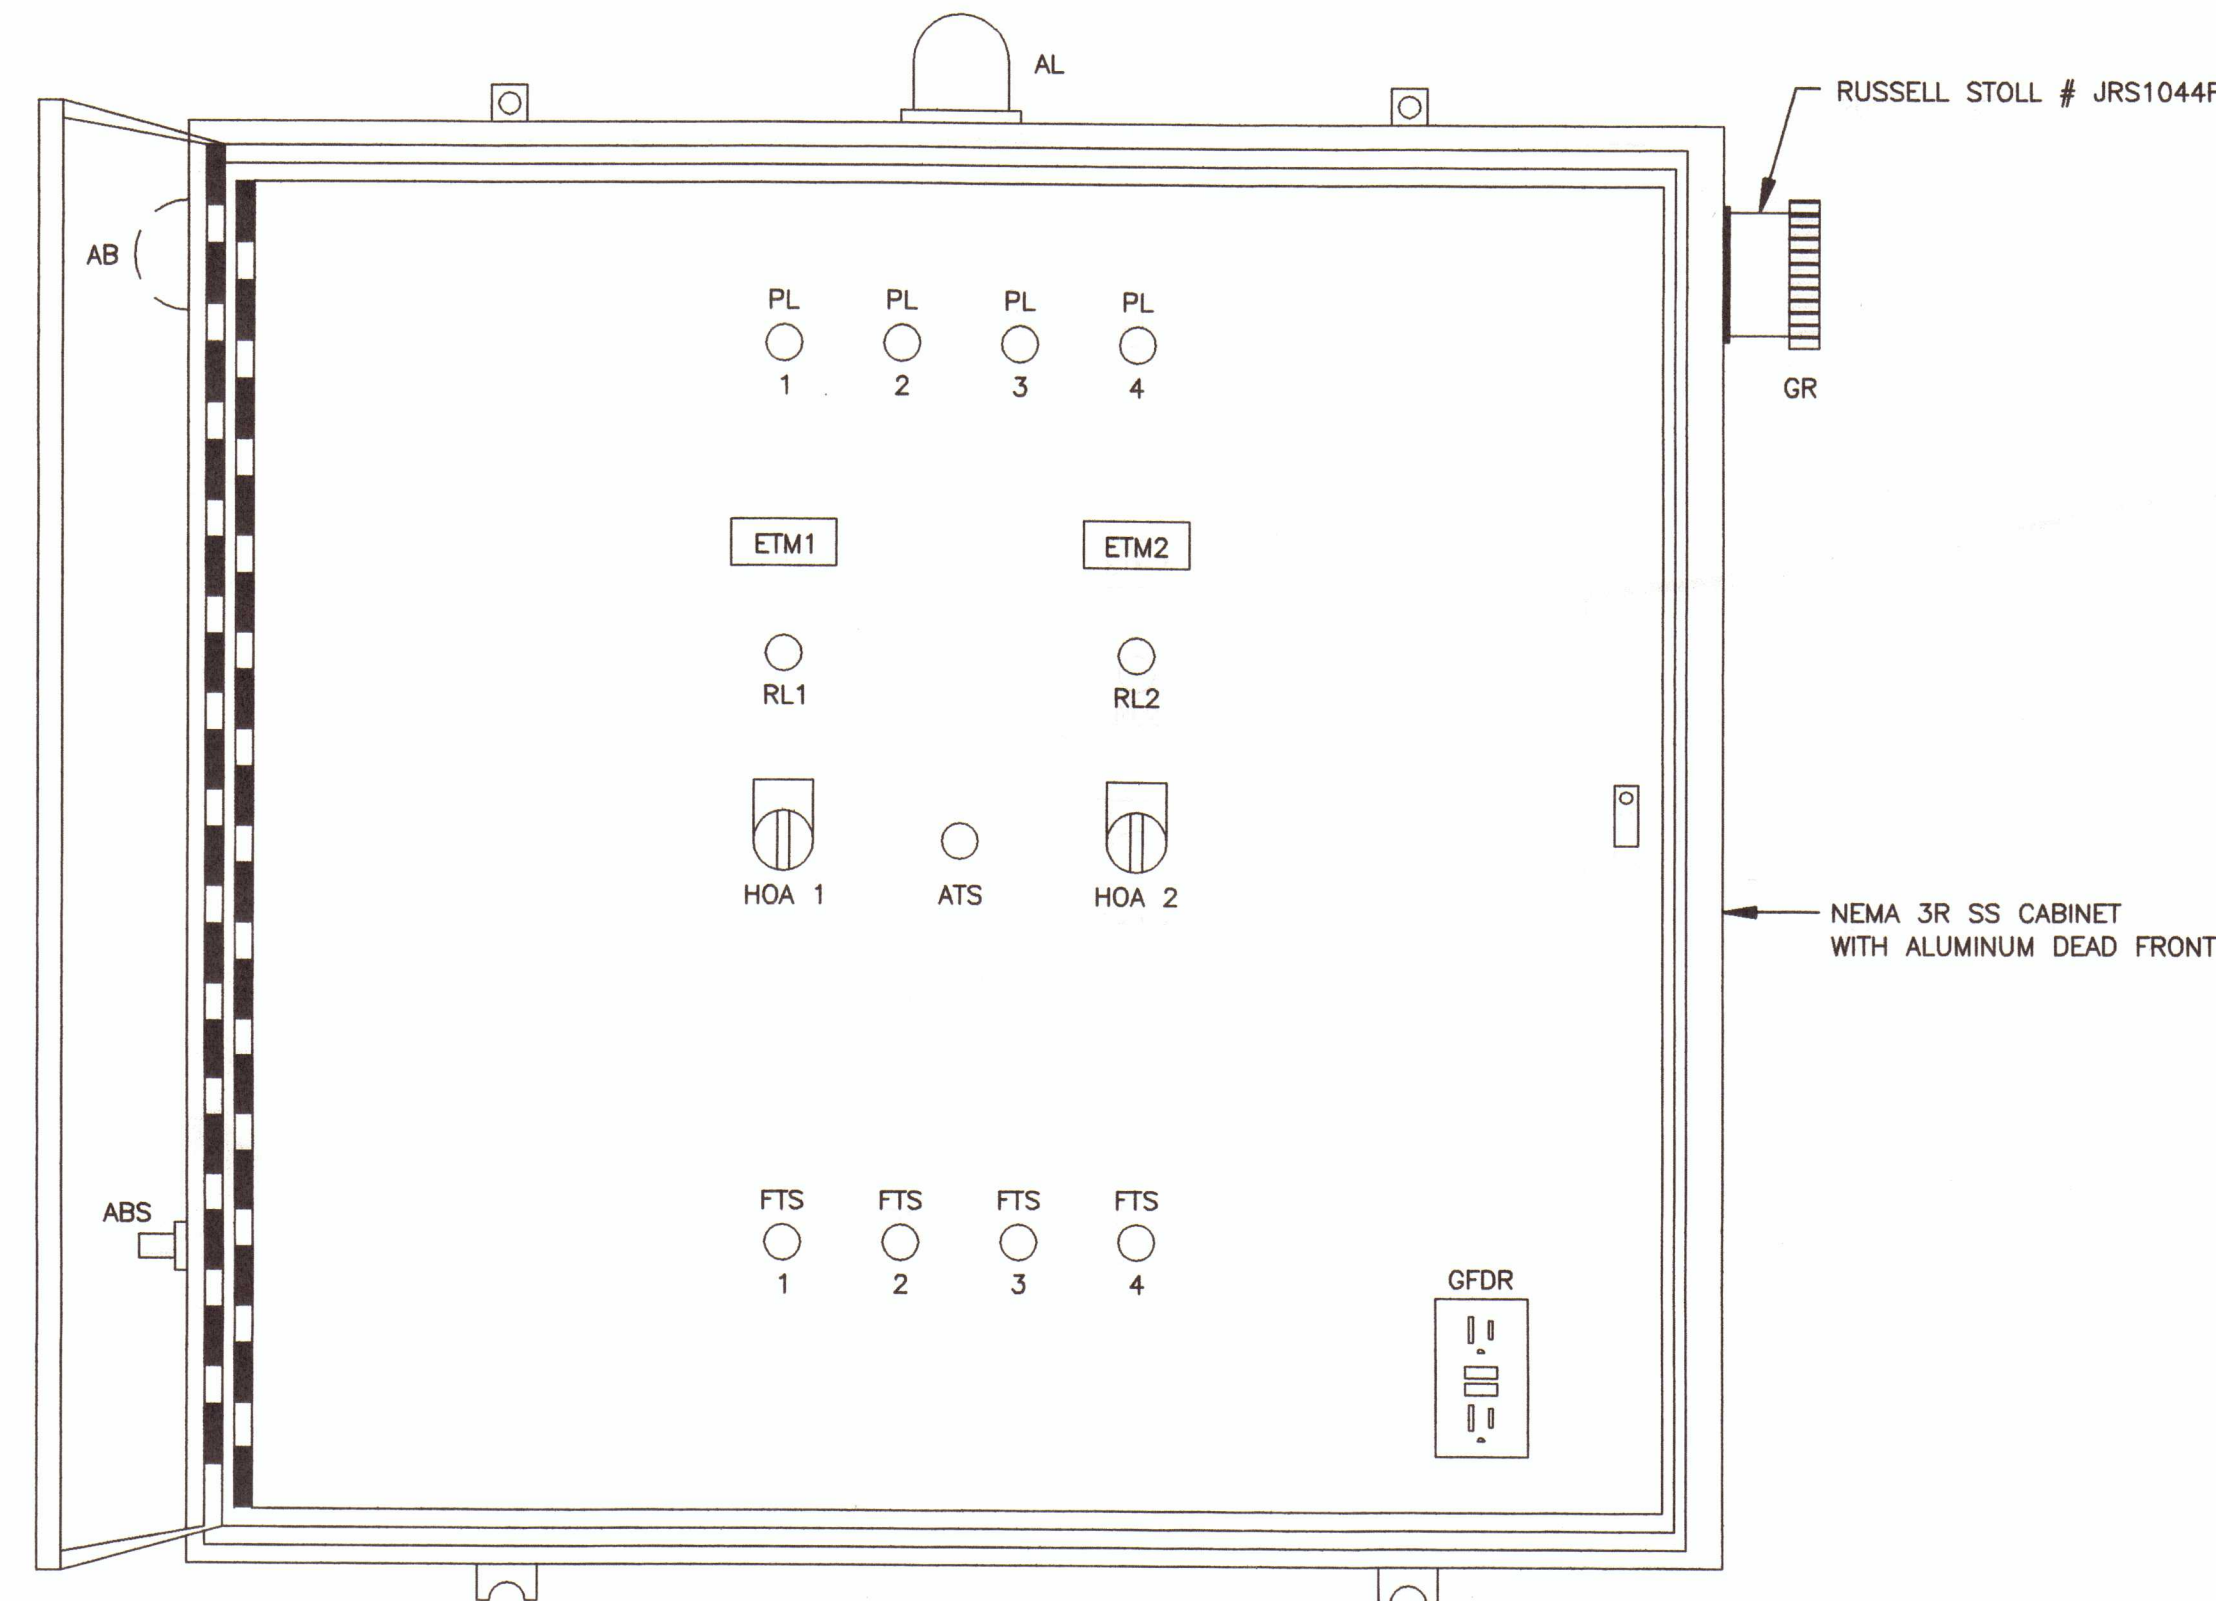

CONTROL PANEL - FRONT VIEW
 N.T.S.

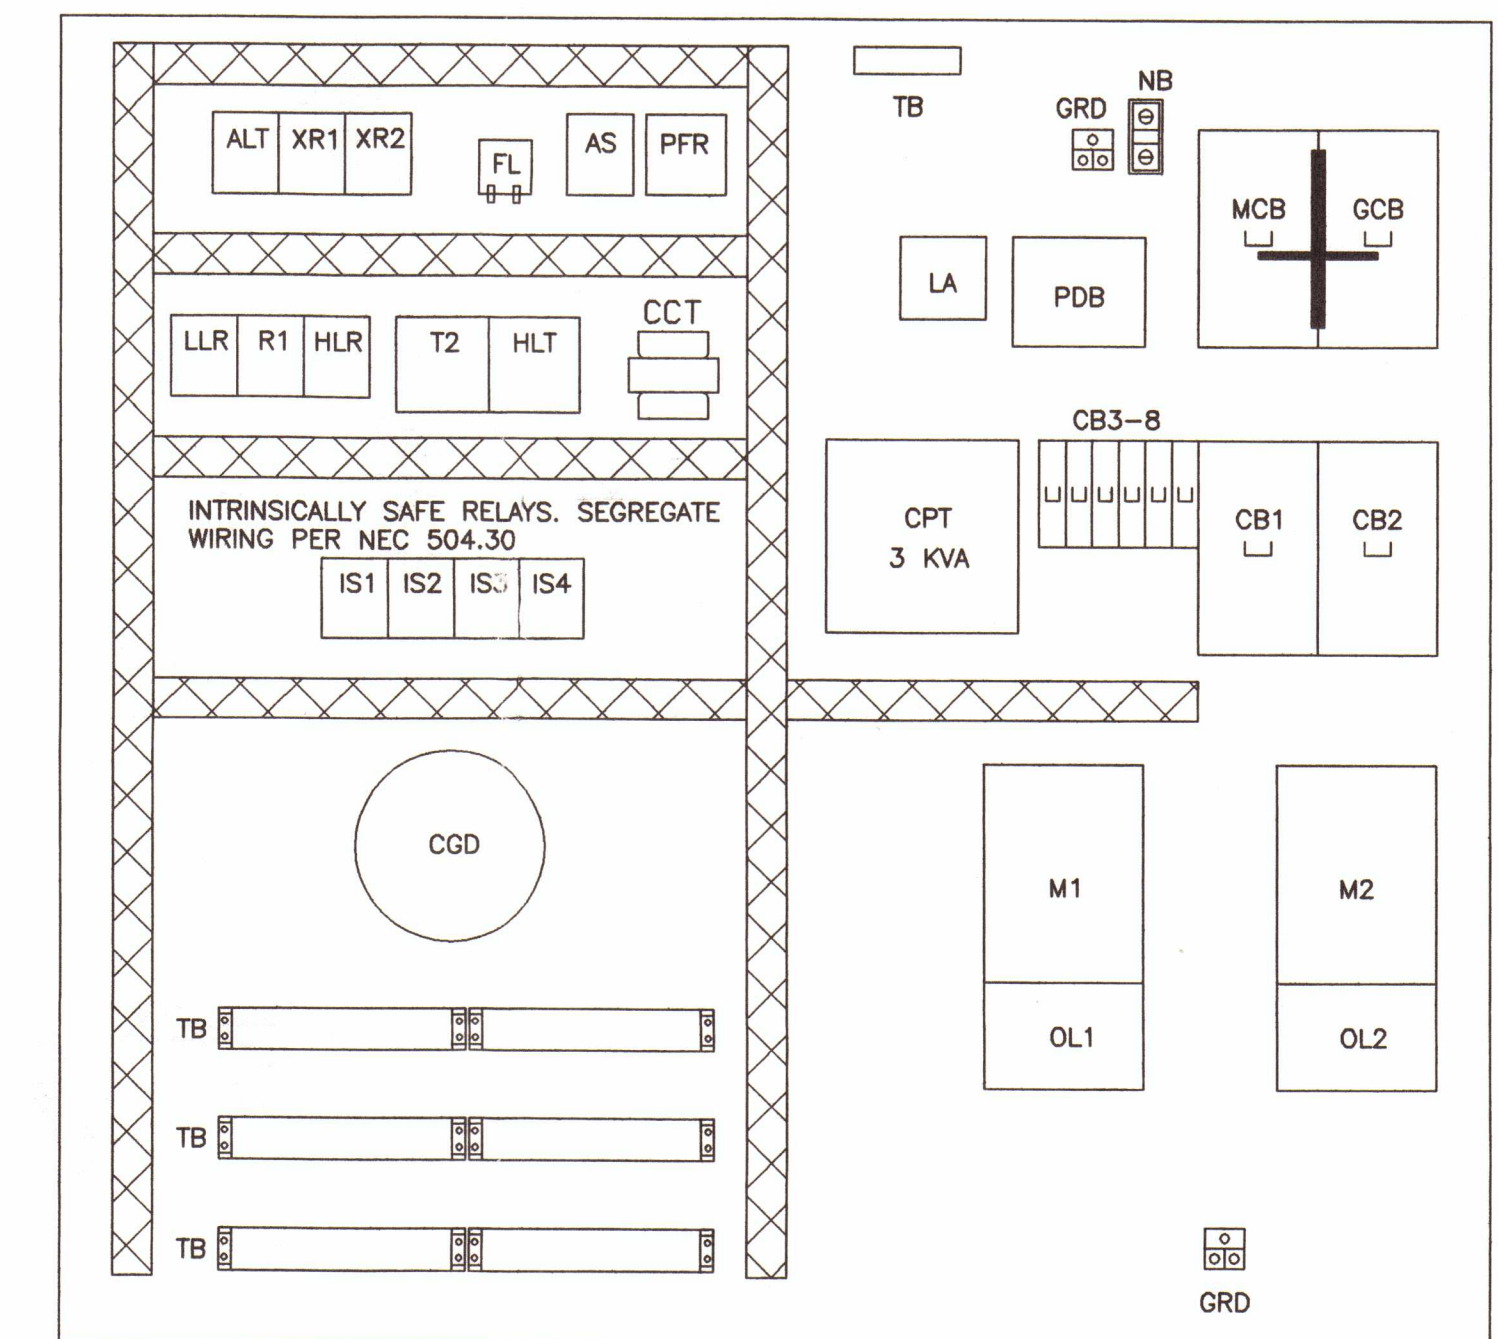

CONTROL PANEL - BACKPLATE LAYOUT
 N.T.S.

Build as Shown
 Refer to O's M's
 A

CHARLES S. STEIN, P.E.
 Florida P.E. #39324
 23055 Post Gardens Way, #133
 Boca Raton, Florida 33433
 (561) 392-5348 - SteinCS@aol.com
 www.gladspower.com

REV. NO.	DATE	DRWN	CHKD	REMARKS

DESIGNED BY: C. STEIN
 DRAWN BY: C. STEIN
 SHEET CHK'D BY: P. LEFAVE
 CROSS CHK'D BY: A. ROSS
 APPROVED BY: C. STEIN
 DATE: AUGUST 2003

CDM Camp Dresser & McKee Inc.
 consulting engineering construction operations
 1819 Main Street, Suite 1002
 Sarasota, Florida 34236
 Tel: 941-563-9696
 FL Cert. of Authorization No. 20

TOWN OF LONGBOAT KEY, FLORIDA

LIFT STATION A IMPROVEMENTS

CONFORMED DRAWINGS
 NOVEMBER 2003

ELECTRICAL LAYOUT

JAN 9 2004


Charles S. Stein
 11/17/2003
 CHARLES S. STEIN
 P.E. NO. 39324

PROJECT NO. 2790-38413
 FILE NAME: E03.dwg

SHEET NO.


E-3

APPLICANT

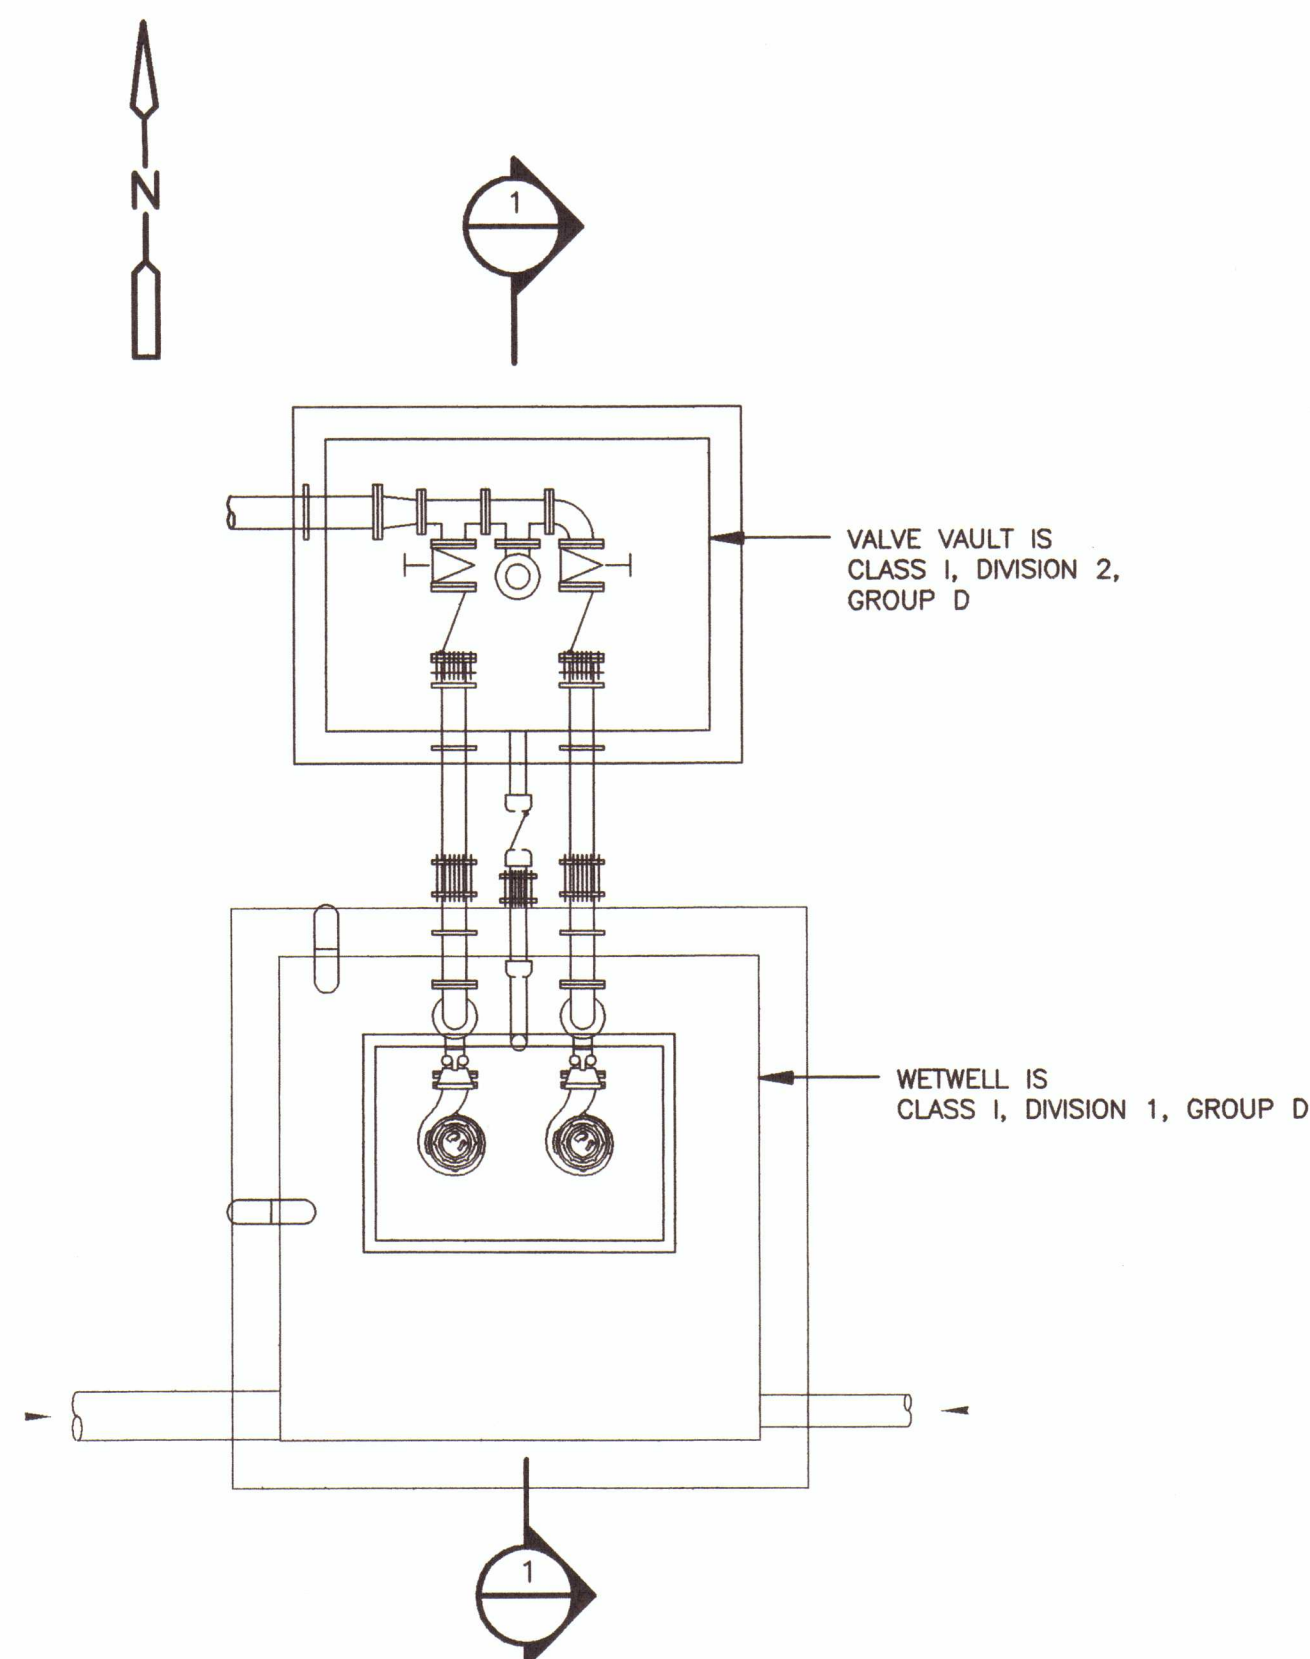


WETWELL AND VALVE VAULT PLAN

N.T.S.

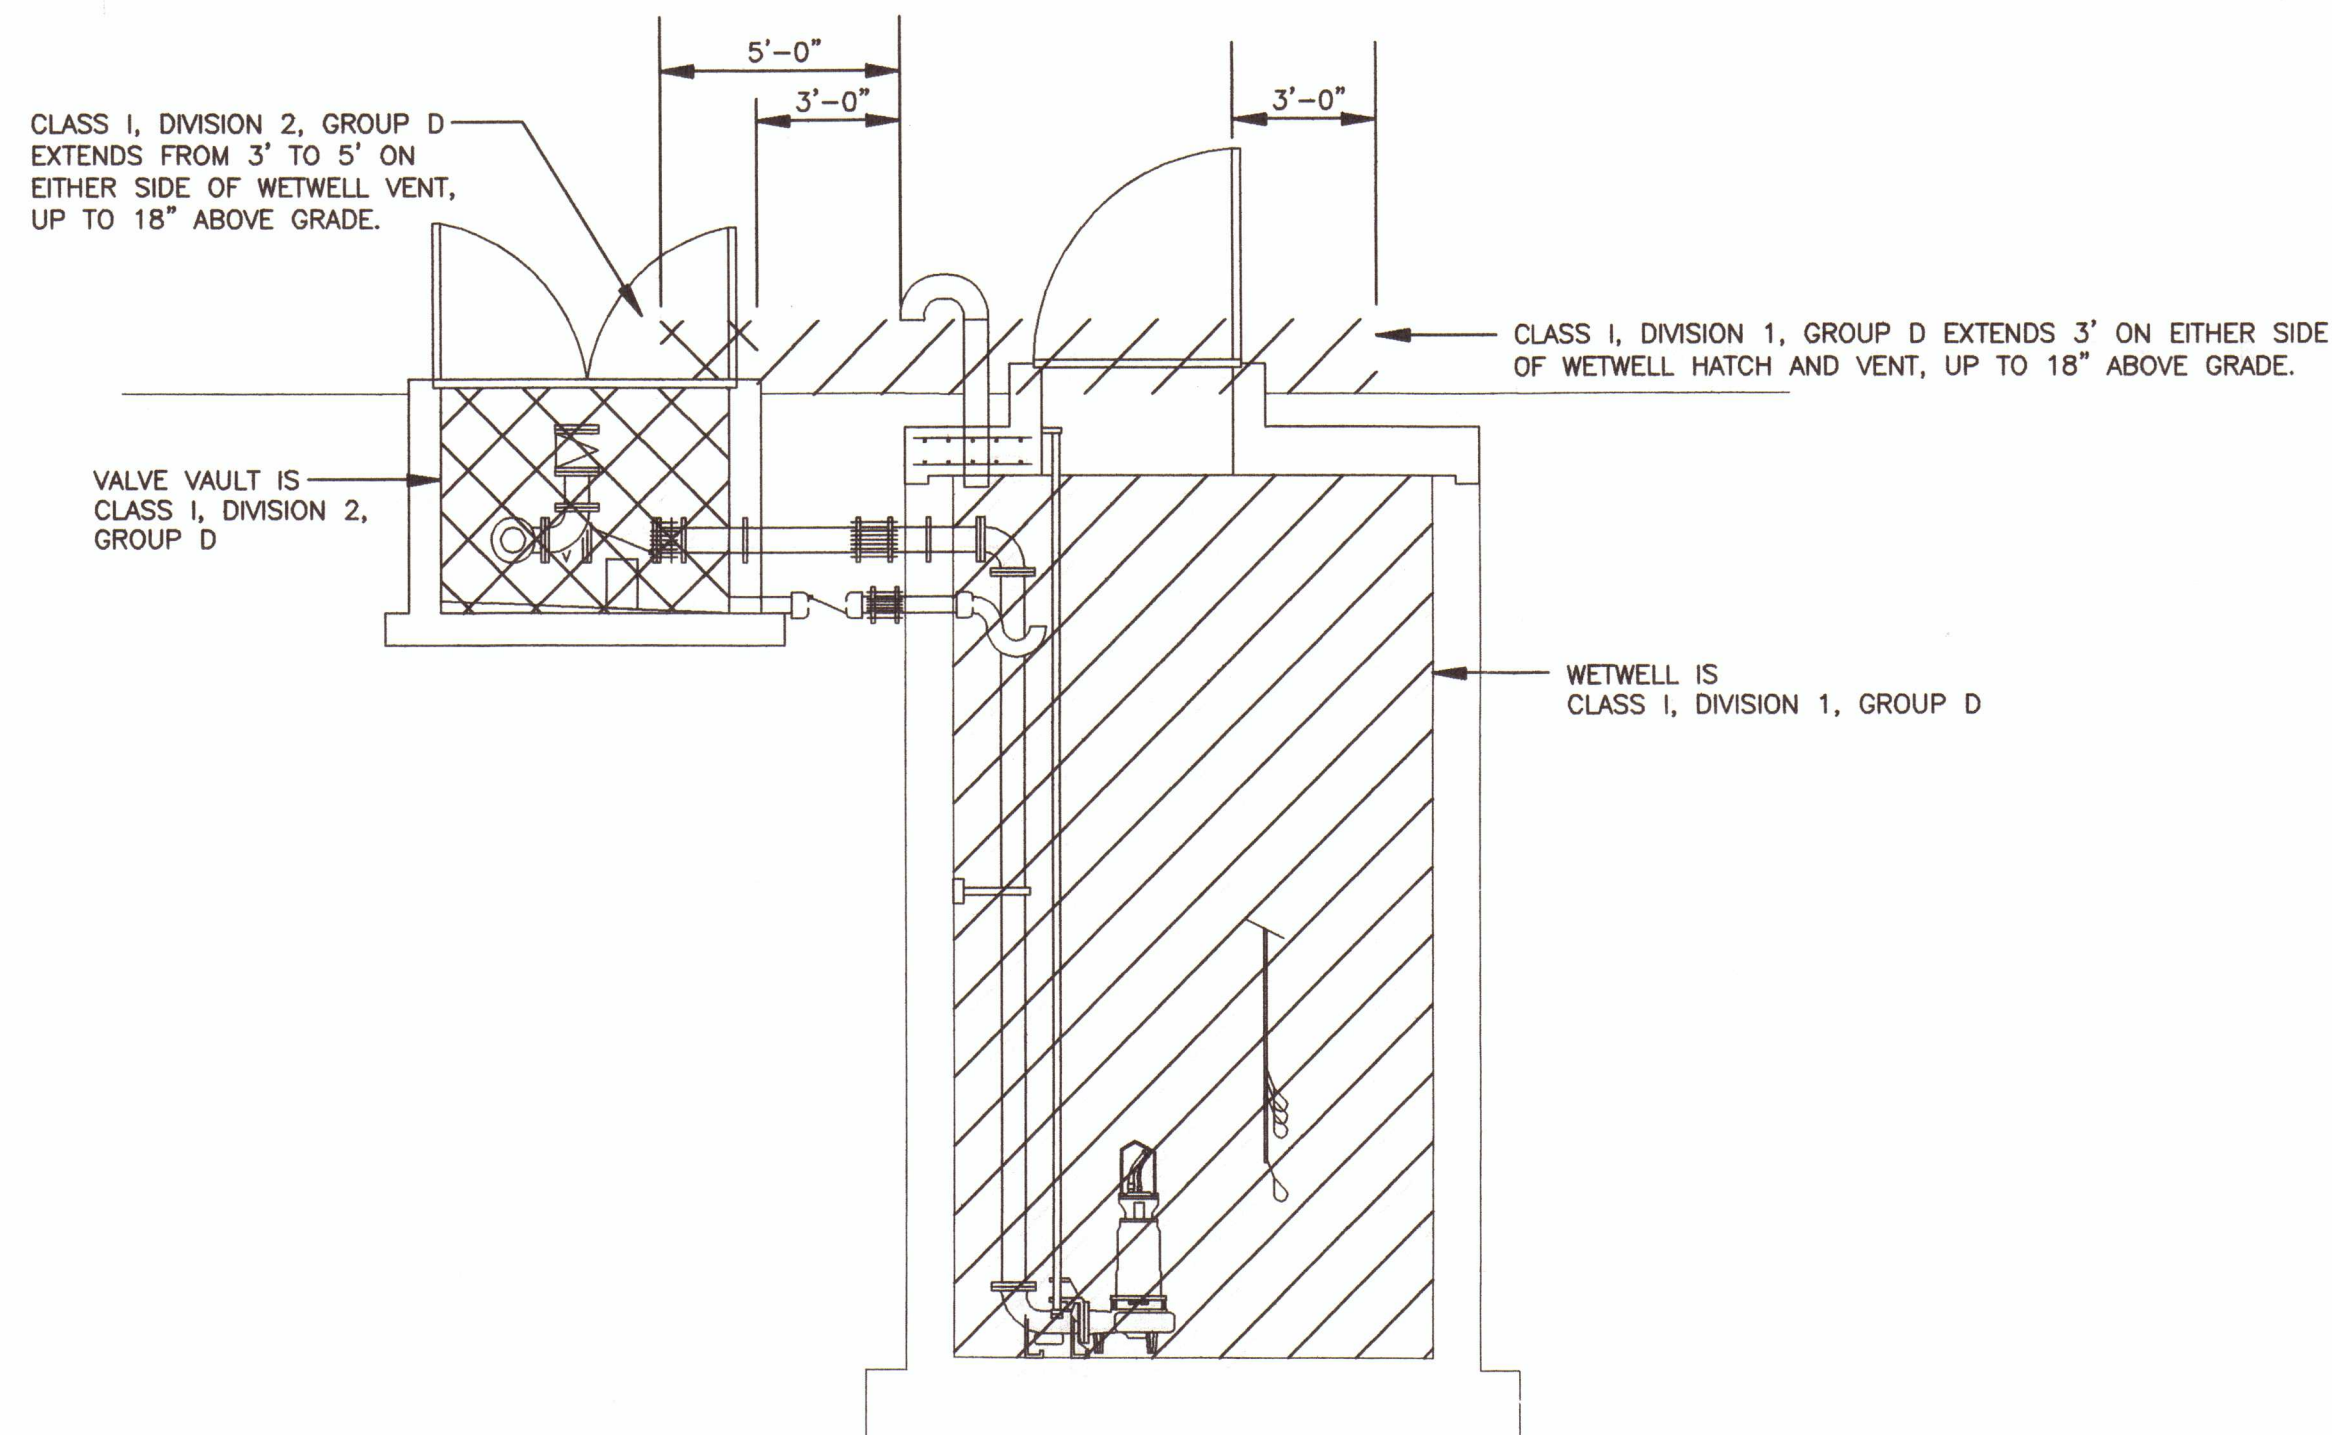


SECTION 1 - WETWELL AND VALVE VAULT

N.T.S.

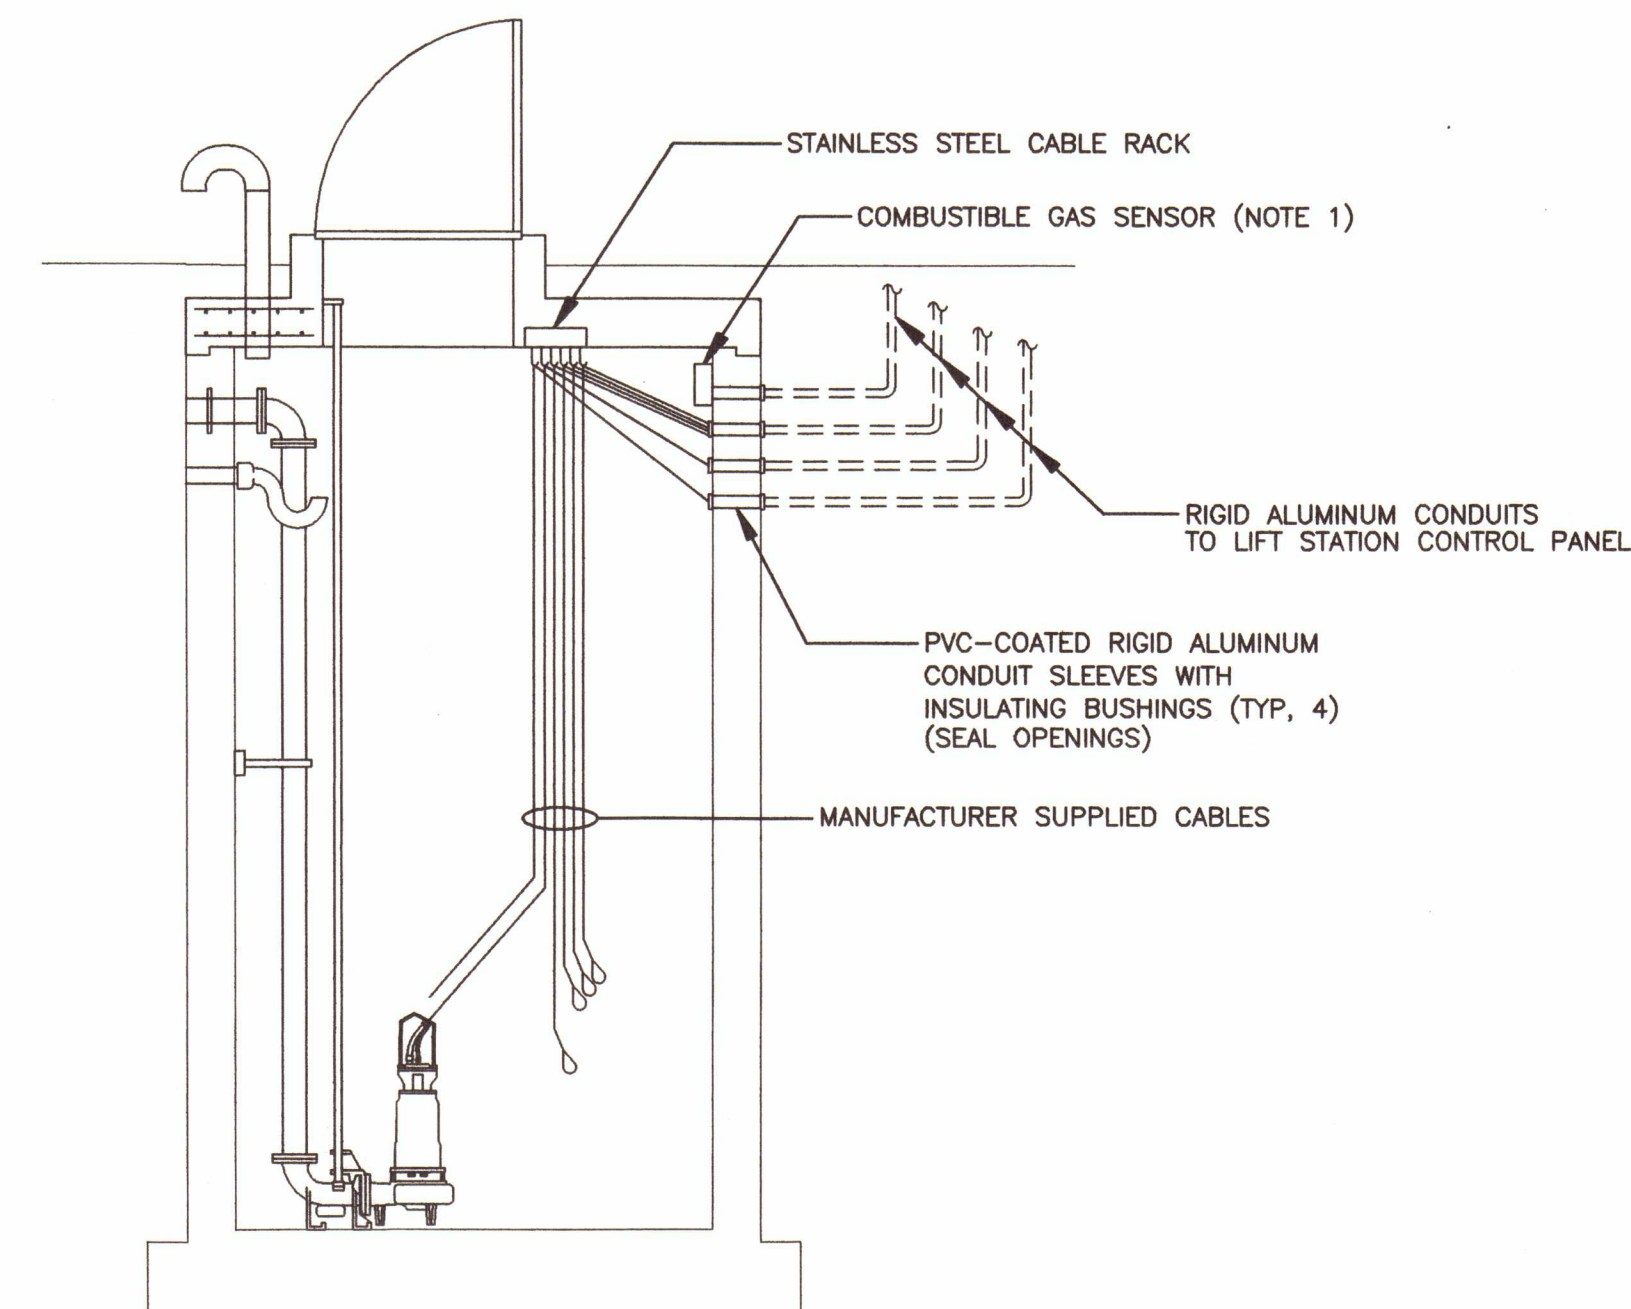


DETAIL A - WETWELL WIRING

N.T.S.

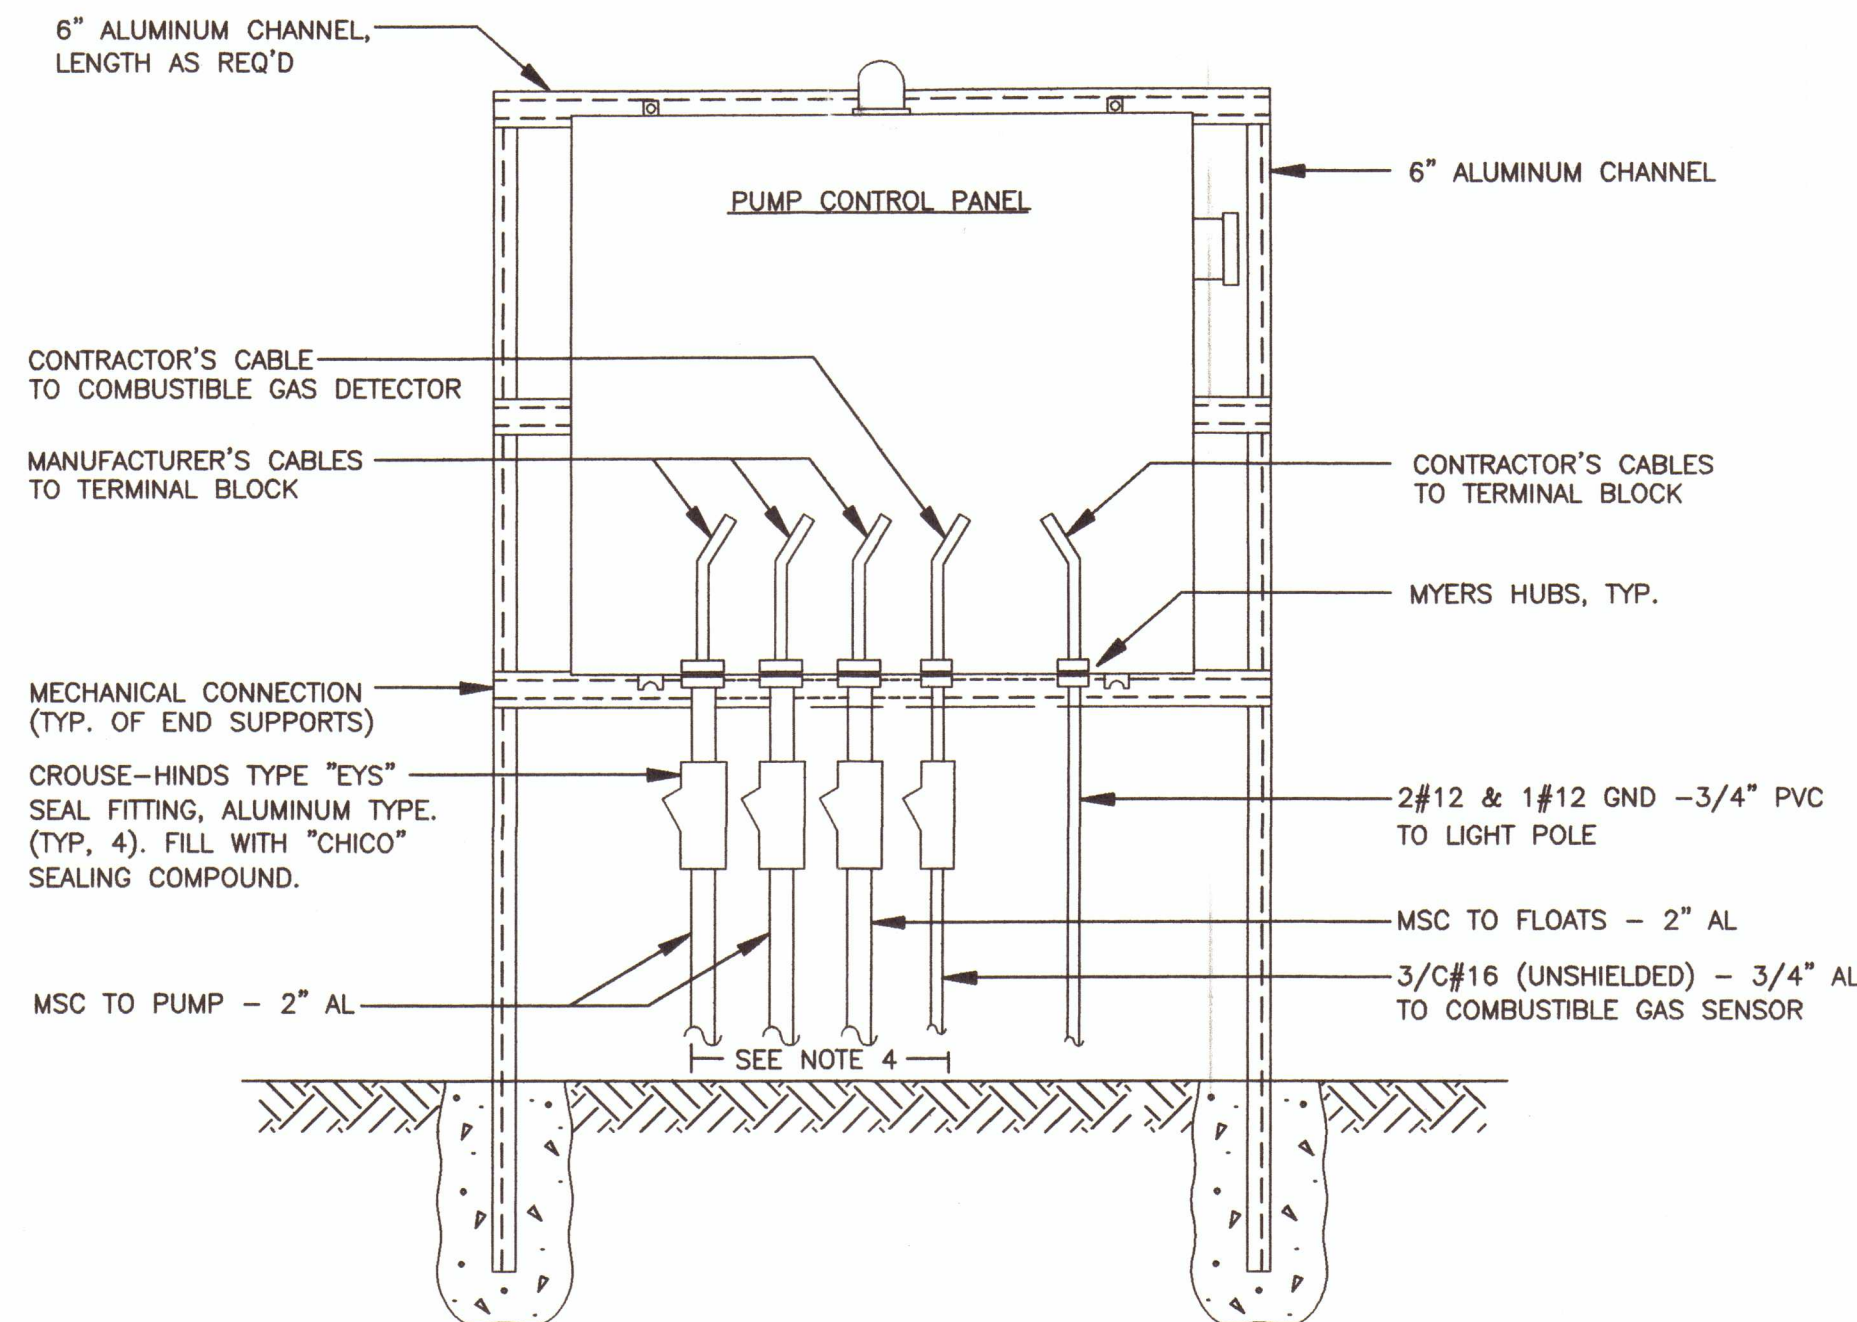

EQUIPMENT RACK & CONDUIT DETAIL (FRONT)

N.T.S.

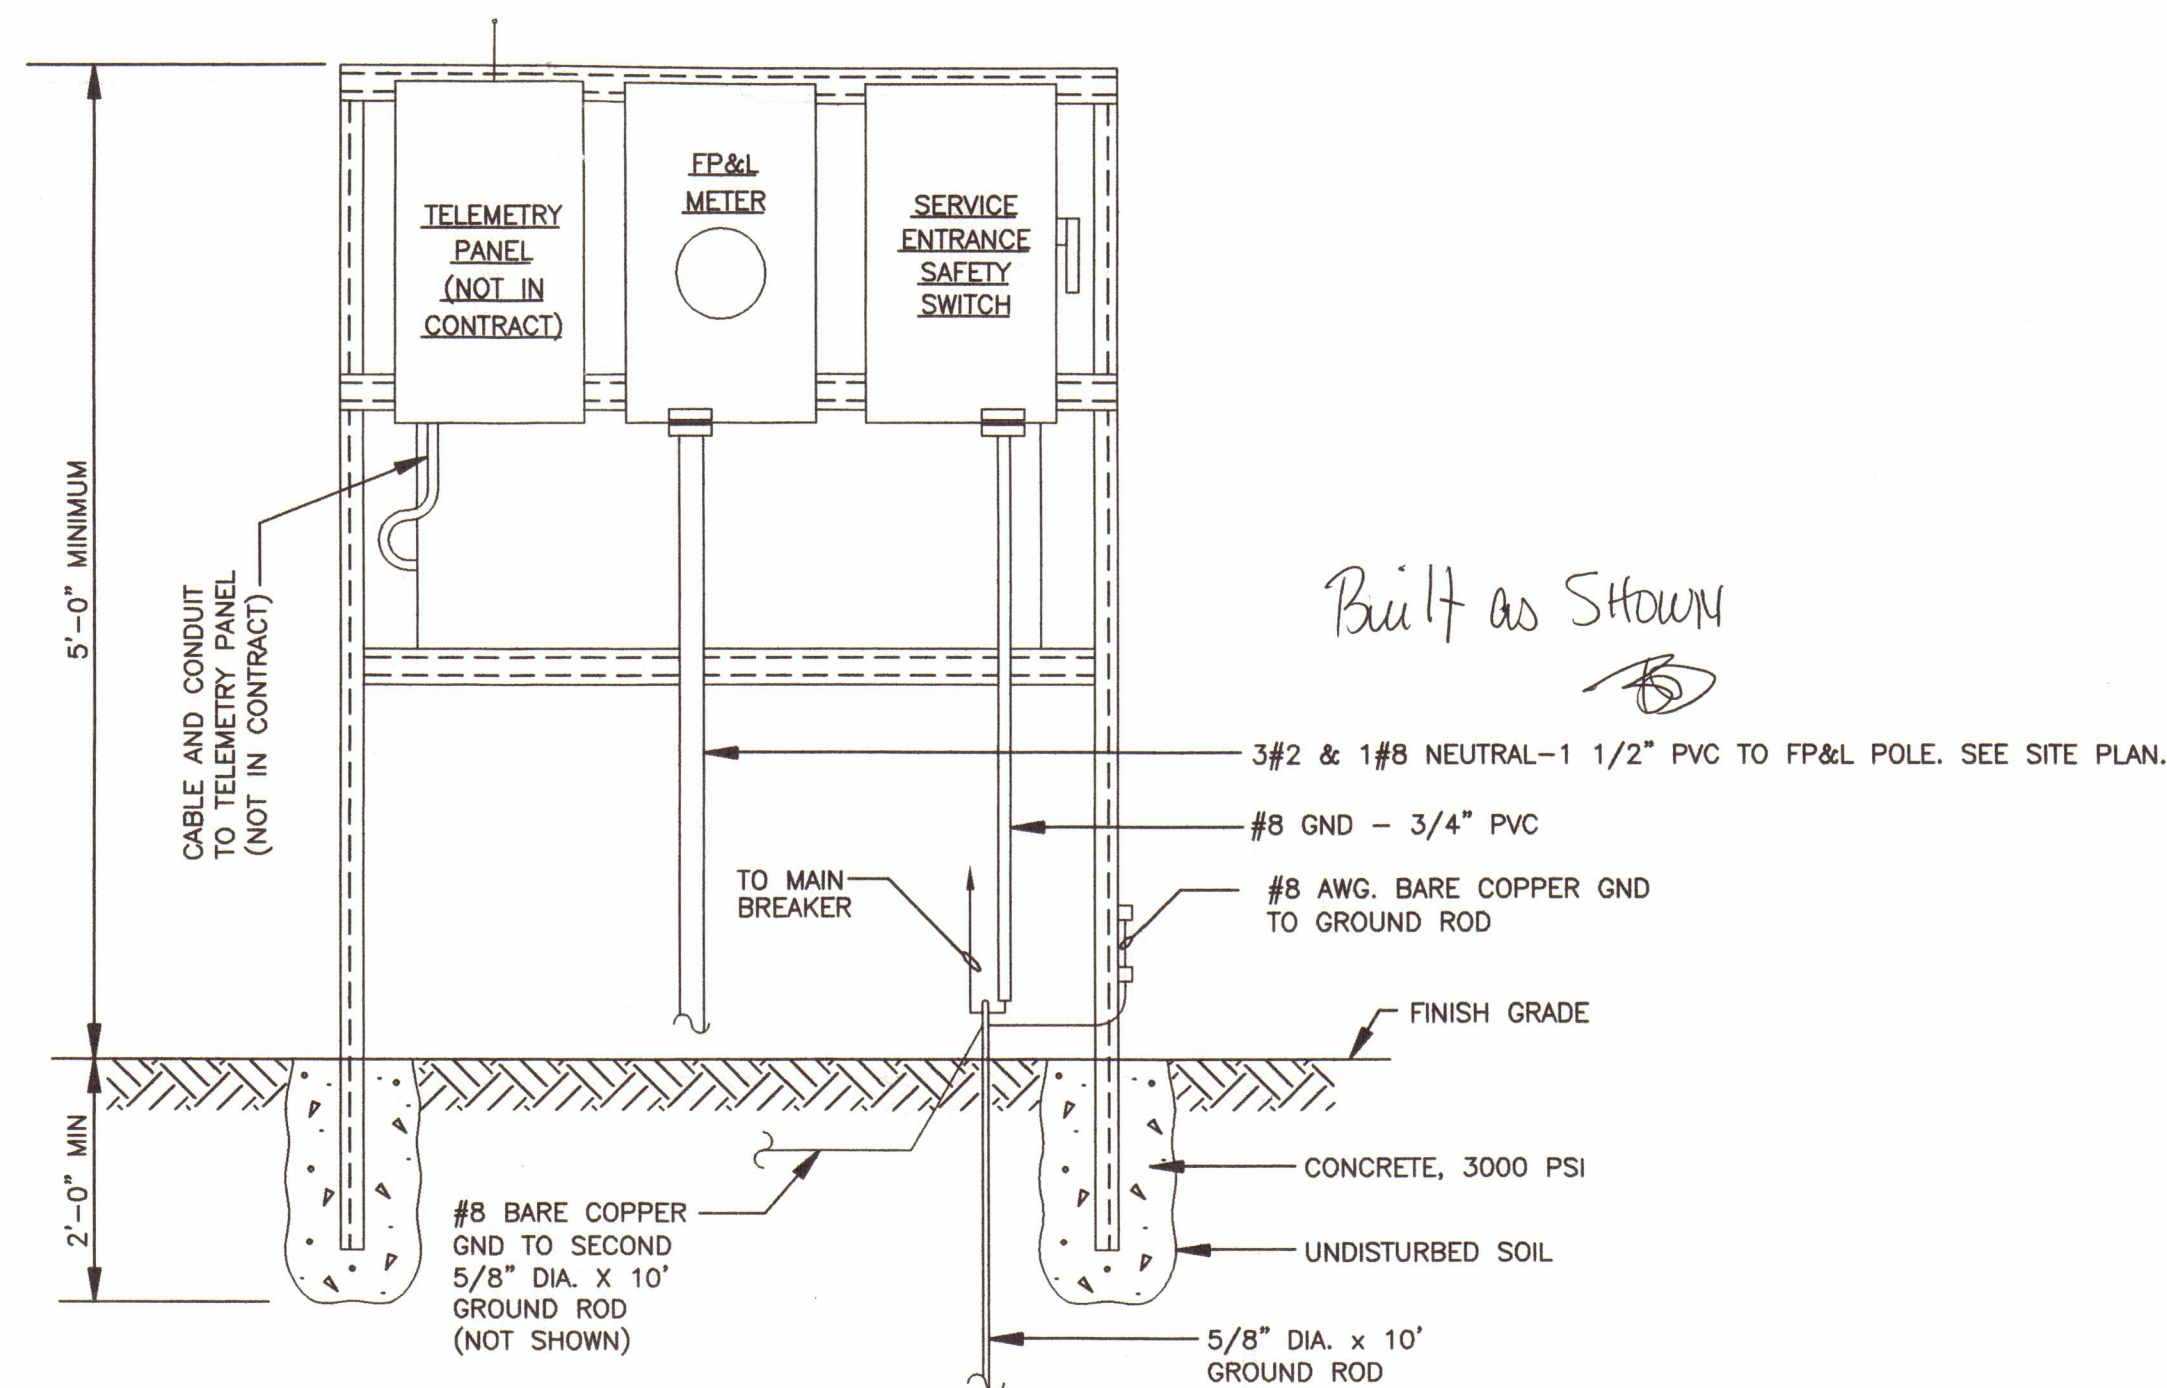

EQUIPMENT RACK & CONDUIT DETAIL (REAR)

N.T.S.

ABBREVIATIONS

AL - RIGID ALUMINUM CONDUIT
MSC - MANUFACTURER SUPPLIED CABLE
PVC - SCHEDULE 80 PVC CONDUIT

NOTES

1. ROUTE 1/4" PVC FLEX TUBING ADJACENT TO CONDUIT FOR COMBUSTIBLE GAS SENSOR. TUBING IS CALIBRATION GAS FEED. TERMINATE ONE END OF TUBING AT GAS SENSOR. TERMINATE OTHER END AT CONVENIENT LOCATION ON ELECTRICAL EQUIPMENT RACK.
2. CONDUIT FROM FP&L METER TO SAFETY SWITCH IS NOT SHOWN.
3. CONDUIT FROM SAFETY SWITCH TO CONTROL PANEL IS NOT SHOWN.
4. FOR CONTINUATION OF CONDUIT AND WIRING TO WETWELL, SEE DETAIL A, THIS SHEET.

CHARLES S. STEIN, P.E.
Florida P.E. #39324
23055 Post Gardens Way, #133
Boca Raton, Florida 33433
(561) 392-5346 - SteinCS@aol.com
www.gladepower.com

REV. NO.	DATE	DRWN	CHKD	REMARKS

DESIGNED BY: C. STEIN
DRAWN BY: C. STEIN
SHEET CHK'D BY: P. LEFAVE
CROSS CHK'D BY: A. ROSS
APPROVED BY: C. STEIN
DATE: AUGUST 2003

CDM Camp Dresser & McKee Inc.
1819 Main Street, Suite 1002
Sarasota, Florida 34236
Tel: 941-363-9696
FL Cert. of Authorization No. 20

TOWN OF LONGBOAT KEY, FLORIDA

LIFT STATION A IMPROVEMENTS

CONFORMED DRAWINGS
NOVEMBER 2003

WETWELL PLAN AND SECTION /
EQUIPMENT RACK DETAILS

JAN 9 2004

Charles S. Stein
11/17/2003

CHARLES S. STEIN
P.E. NO. 39324

PROJECT NO. 2790-38413
FILE NAME: E04.dwg

SHEET NO.

E-4
APPLICANT

WASTEWATER SYSTEM IMPROVEMENTS FOR TOWN OF LONGBOAT KEY, FLORIDA

APPROVED: 2/25/04
DATE: 2/25/04
PERMIT APPROVAL IS CONDITIONED ON FULL COMPLIANCE
WHEN FIELD INSPECTED WITH ALL PROVISIONS OF THE
CODES OF THE TOWN OF LONGBOAT KEY & ALL OTHER
APPLICABLE LAWS. ALL BUILDINGS, A/C, PLUMBING,
MECHANICAL, ELECTRICAL, GAS & FIRE INSTALLATIONS SHALL
BE MADE BY LICENSED CONTRACTORS & FOR RESIDENTIAL
HOMEOWNERS.
BLDG: _____ ELEC: _____
PLUMBING: _____ MECH: _____
GAS: _____ ROOF: _____ FIRE: _____
PERMIT NO.: BP 20014
REVIEWED FOR CODE COMPLIANCE

APPLICANT



REGISTERED ENGINEERS
STATE OF FLORIDA

PROJECT MANAGER


Laura S. Andrews
LAURA S. ANDREWS, P.E., DEC
NO. 47683
11/19/03

GENERAL
CIVIL
MECHANICAL

Anne L. Ross
ANNE L. ROSS, P.E.
NO. 56976
11/18/03

ELECTRICAL

Charles S. Stein
CHARLES S. STEIN, P.E.
NO. 39324
11/17/2003

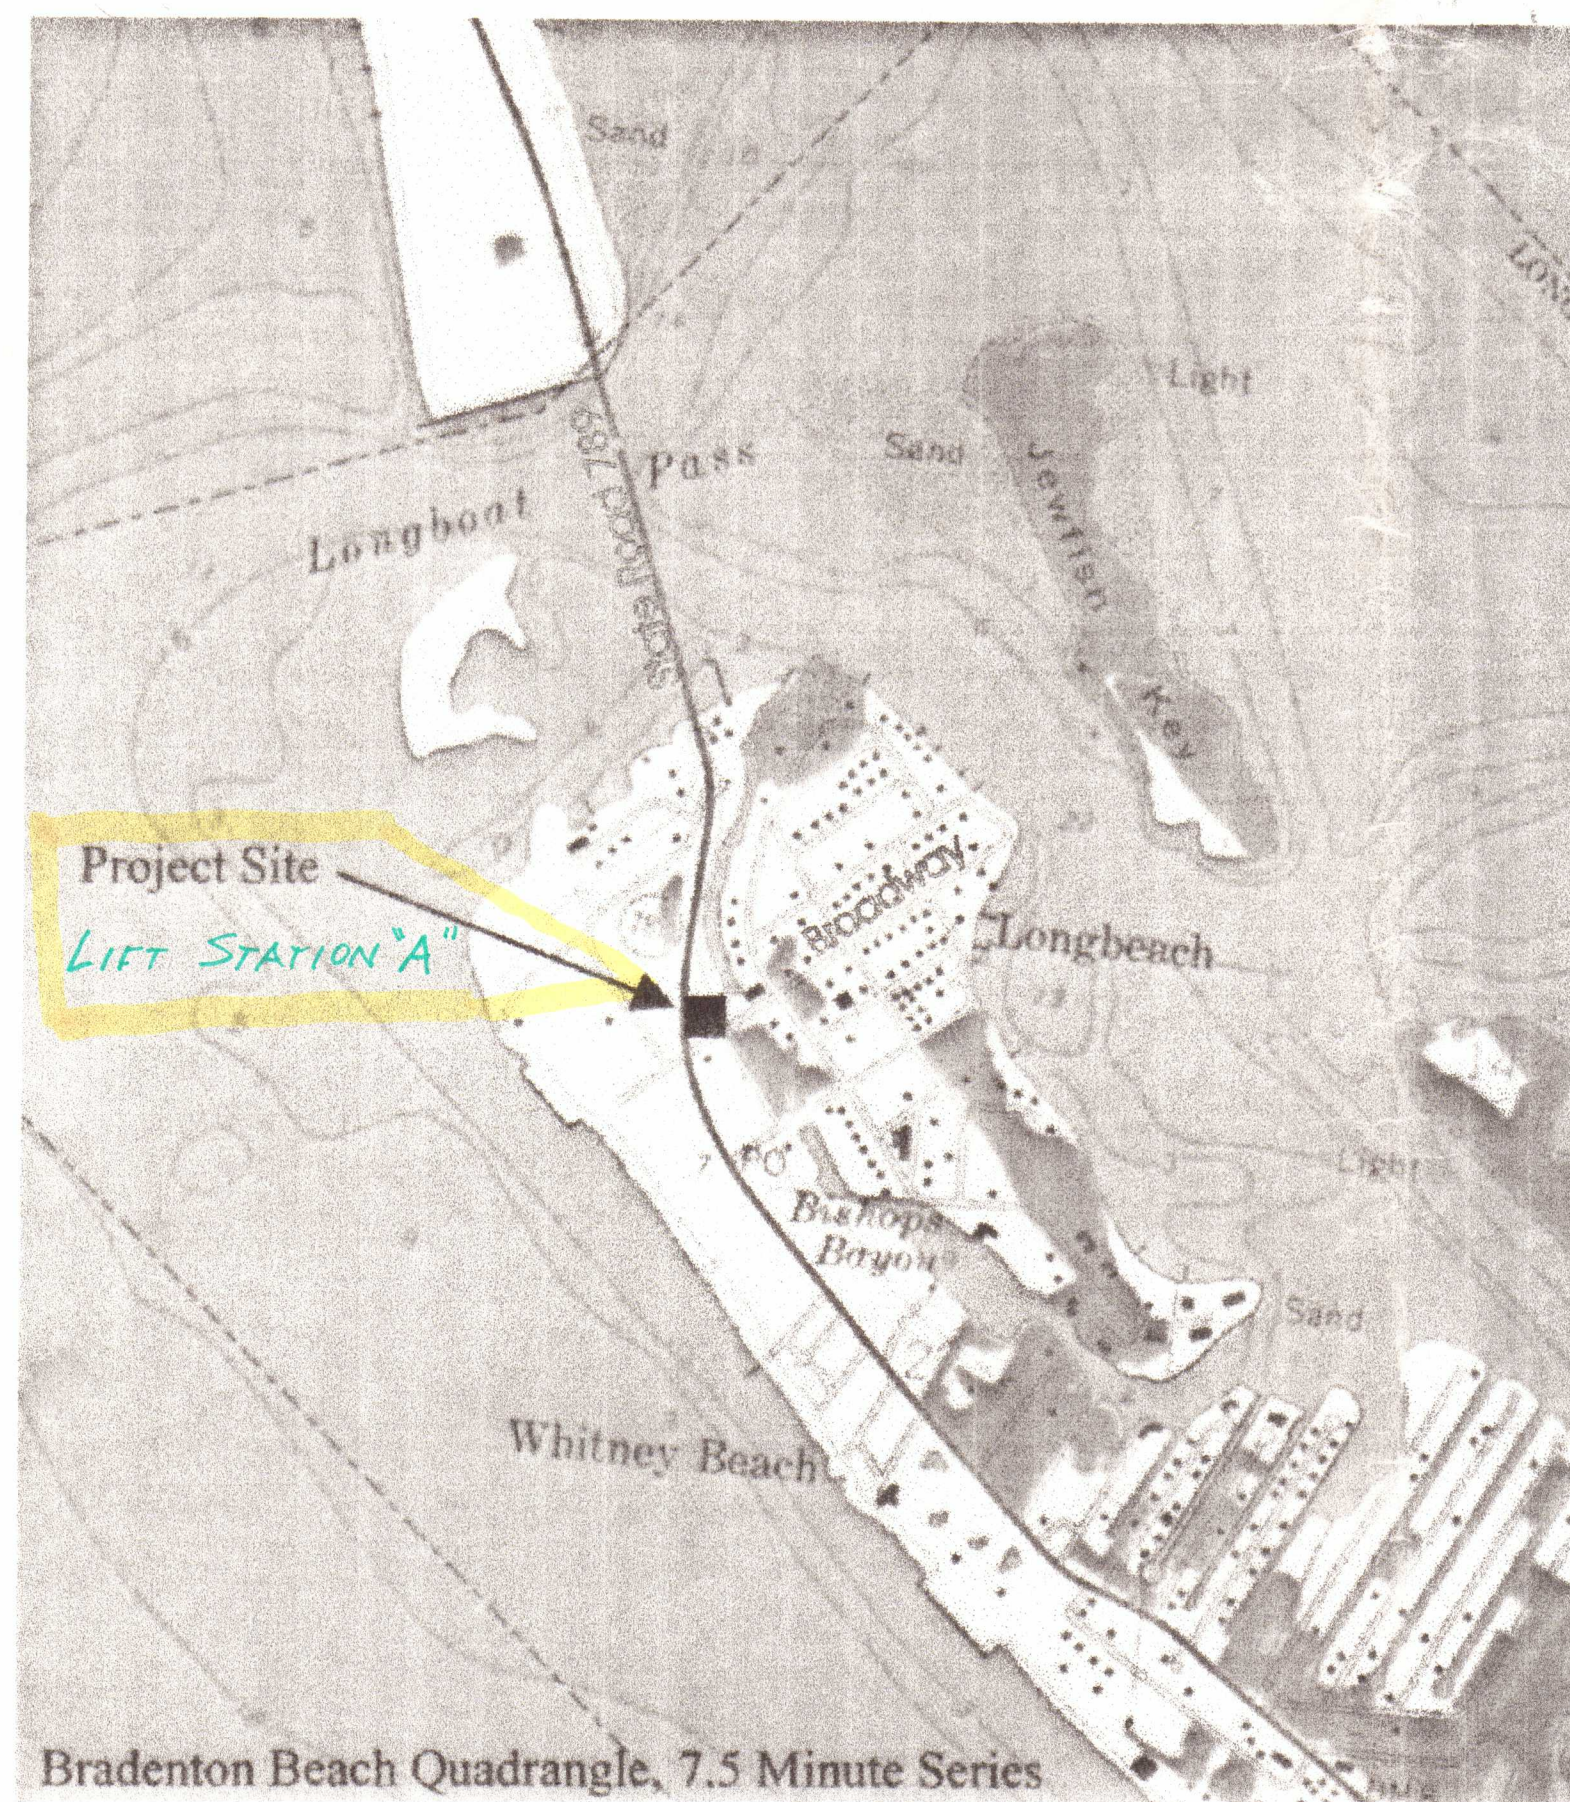

LIFT STATION A IMPROVEMENTS

RECORD DRAWINGS

August 2003

CAMP DRESSER & McKEE INC.


1819 MAIN STREET, SUITE 1002
SARASOTA, FLORIDA 34236
TEL: 941-363-9696
FL. CERT. OF AUTHORIZATION NO. 20

PROJECT NUMBER: 2790-38413

INDEX OF SHEETS

SHEET	TITLE
GENERAL	
	COVER
G-1	GENERAL NOTES, LEGEND AND ABBREVIATIONS
SP-1	SPECIFIC PURPOSE SURVEY
CIVIL	
C-1	SITE PLANS
MECHANICAL	
M-1	LIFT STATION A DEMOLITION PLAN AND SECTION
M-2	LIFT STATION A MODIFICATION PLAN AND SECTION
MD-1	MISCELLANEOUS DETAILS
ELECTRICAL	
E-1	ELECTRICAL SITE PLAN
E-2	POWER AND CONTROL DIAGRAMS
E-3	ELECTRICAL LAYOUT
E-4	WETWELL PLAN AND SECTION/EQUIPMENT RACK DETAILS

CONFORMED DRAWINGS
NOVEMBER 2003

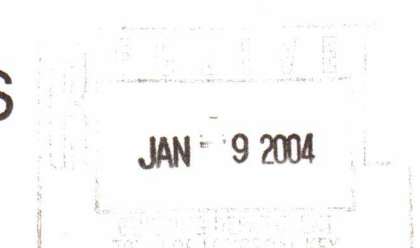

consulting
engineering
construction
operations

CDM

SITE LOCATION MAP
NTS

RECORD DRAWINGS
LIFT STATION "A"

GENERAL

SYMBOLS

GENERAL (CONT.)

PIPE

ASBESTOS CEMENT PIPE
BLACK STEEL PIPE
CAST IRON
CAST IRON PIPE
CAST IRON SOIL PIPE
CONCRETE PRESSURE PIPE
COPPER PIPE
CORRUGATED METAL PIPE
DUCTILE IRON PIPE
DUCTILE IRON
FIBERGLASS REINFORCED PIPE
FLANGE
GALVANIZED STEEL PIPE
MECHANICAL JOINT
METAL REINFORCED PLASTIC PIPE
POLYETHYLENE PIPE
POLYVINYLCHLORIDE
REINFORCED CONCRETE PIPE
RESTRAINED JOINT
SLIP-ON JOINT
STEEL PIPE
TIED JOINT
VITRIFIED CLAY PIPE

SYMBOLS



WTR.	10" R.W.	EXISTING 10" WATER MAIN
WL	 SAN. S. _____	EXISTING SANITARY SEWER W/ MANHOLE
WM	_____ 10" F.M. _____	EXISTING FORCE MAIN
WPF.	_____ T _____	EXISTING BURIED TELEPHONE
W.	_____ P _____	EXISTING POWER DUCTS OR CABLES
W/	_____ O.H.P. _____	OVERHEAD POWER
	_____ CATV _____	EXISTING CABLE TELEVISION
	C.B.  15" S.S. _____	EXISTING STORM SEWER W/CATCH BASIN
	 F.H.	FIRE HYDRANT
	_____ - - - - - T _____	R/W - RIGHT OF WAY
	_____ _____	P - PROPERTY LINE

SYMBOLS


ACCV
ARV
BCV
BAV
B.F.
BO
BV
CV
EVA
EO
EXJ
FH
FTG
FA
FC
FB
FS
GV
HFAC
HB
HVA
MJP
PBV
PCV
PV
PCV
SCV
SDCV
UN
VB
VC (G)
VC (S)
WS
WAP

NEW MAIN THIS PROJECT

 20" W.M.	EXISTING WATER MAIN
 16" R.W.	EXISTING RAW WATER MAIN
 M.H. SAN. S.	EXISTING SANITARY SEWER W/ MANHOLE
 10" F.M.	EXISTING FORCE MAIN
 T	EXISTING BURIED TELEPHONE
 P	EXISTING POWER DUCTS OR CABLES
 O.H.P.	OVERHEAD POWER
 CATV	EXISTING CABLE TELEVISION
 C.B. 15" S.S.	EXISTING STORM SEWER W/CATCH BASIN
 F.H.	FIRE HYDRANT
	R/W - RIGHT OF WAY
	R - PROPERTY LINE

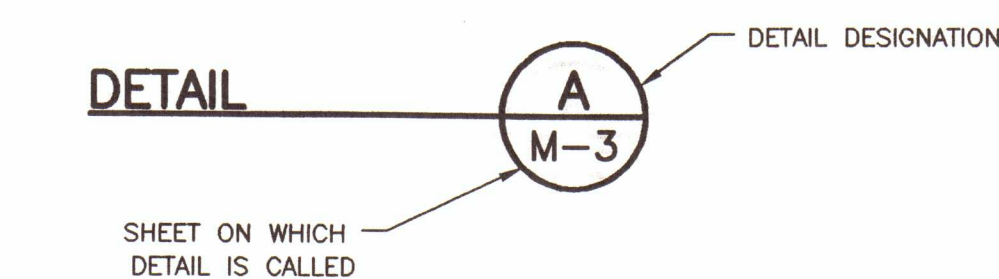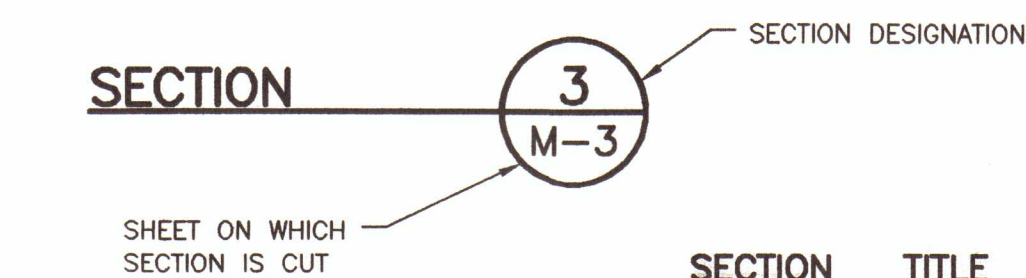

DETAIL TITLE TARGET
SECTION AND DETAIL NUMBERING SYSTEM
N.T.S.

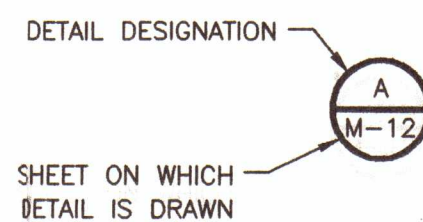

LOCATIONS, ELEVATIONS AND DIMENSION OF EXISTING UTILITIES STRUCTURES AND OTHER FEATURES ARE SHOWN ACCORDING TO THE BEST INFORMATION AVAILABLE AT THE TIME OF PREPARATION OF THESE PLANS. BUT DO NOT PURPORT TO BE ABSOLUTELY CORRECT. PRIOR TO CONSTRUCTION, THE CONTRACTOR SHALL VERIFY AND AGREE TO BE FULLY RESPONSIBLE FOR ANY AND ALL DAMAGES WHICH MIGHT BE OCCASIONED BY HIS FAILURE TO EXACTLY LOCATE AND PRESERVE ANY AND ALL EXISTING UTILITIES, STRUCTURES, AND OTHER FEATURES AFFECTING HIS WORK. ANYTHING NOT SHOWN ON THESE DRAWINGS SHOULD BE BROUGHT TO THE ATTENTION OF THE ENGINEER AND SHALL NOT CONSTITUTE AN EXTRA, UNLESS APPROVED BY THE ENGINEER.

2. THE CONTRACTOR SHALL CONTACT THE ENGINEER'S OFFICE IMMEDIATELY CONCERNING ANY CONFLICTS ARISING DURING CONSTRUCTION OF ANY IMPROVEMENTS SHOWN ON THESE DRAWINGS.

3. LOCATION OF EXISTING UTILITIES ARE APPROXIMATE, USING THE BEST AVAILABLE INFORMATION AT THE TIME OF PREPARATION OF THE CONTRACT DOCUMENTS. THE CONTRACTOR SHALL VERIFY ALL UTILITIES AND PROVIDED AT LEAST 48 HOURS NOTICE TO THE INDIVIDUAL UTILITY COMPANIES PRIOR TO CONSTRUCTION. CONTACT SUNSHINE CENTER AT 1-800-432-4770.

FLORIDA POWER & LIGHT TECO PEOPLES GAS
5657 SOUTH MCINTOSH RD. SARASOTA ENGINEERING
SARASOTA, FL 34233 8261 VICO COURT
(941) 927-4216 SARASOTA, FL 34240
CONTACT: SHANNON WRITE (877) 832-6747
CONTACT: TED FELAGEE

VERIZON COMCAST CABLE
1701 RINGLING BLVD. 5205 FRUITVILLE RD.
SARASOTA, FL 34236 SARASOTA, FL 34232
(941) 952-6332 (941) 342-3577
CONTACT: BRYAN LANTZ CONTACT: PHIL BELANGER

TOWN OF LONGBOAT KEY
PUBLIC WORKS DEPARTMENT
600 GENERAL HARRIS STREET
LONGBOAT KEY, FL 34228
(941) 316-1958
CONTACT: KEVIN WEBB

4. ALL JOINTS SHALL BE RESTRAINED IN ACCORDANCE WITH THE SPECIFICATIONS AND AS SHOWN ON THE DRAWINGS.

5. ALL UNDERGROUND FITTINGS FOR PVC/D.I. SHALL BE DUCTILE IRON, WITH MECHANICAL JOINTS WITH HIGH STRENGTH CORROSION RESISTANT ALLOY T-HEAD BOLTS, EQUAL TO "CORTEN". SUBJECT TO THE APPROVAL OF THE ENGINEER.

6. THE INFORMATION PROVIDED IN THESE PLANS IS SOLELY TO ASSIST THE CONTRACTOR IN ASSESSING THE NATURE AND EXTENT OF CONDITIONS WHICH MAY BE ENCOUNTERED DURING THE COURSE OF THE WORK. ALL CONTRACTORS ARE DIRECTED, PRIOR TO BIDDING, TO CONDUCT WHATEVER INVESTIGATIONS THEY MAY DEEM NECESSARY TO ARRIVE AT THEIR OWN CONCLUSION REGARDING THE ACTUAL CONDITIONS THAT WILL BE ENCOUNTERED, AND UPON WHICH THEIR BIDS WILL BE BASED.

7. ALL FIELD TOPOGRAPHIC SURVEYS SHOWN ON DRAWINGS WERE DERIVED FROM A SURVEY PERFORMED BY GEORGE F. YOUNG, 78 SARASOTA CENTER BLVD., SARASOTA, FL 34240. CONTACT: DENNIS HOOVER.

8. ALL SOILS EXPLORATION WORK WAS PERFORMED BY DRIGERS ENGINEERING, SERVICES, INC., P.O. BOX 5166, CLEARWATER, FLORIDA 34618. THE SUBSURFACE INVESTIGATIONS AND ANALYSIS THAT HAVE BEEN ACCOMPLISHED ARE AVAILABLE FOR REVIEW AS PRESCRIBED FOR IN THE SPECIFICATIONS. THE GEOTECHNICAL REPORT IS PROVIDED FOR THE CONTRACTOR'S CONVENIENCE AND IS FOR GENERAL INFORMATION ONLY. THE CONTRACTOR IS SOLELY RESPONSIBLE FOR HIS OWN INTERPRETATIONS OF THE GEOTECHNICAL DATA. THE REPORT IS REPRESENTED TO ONLY PROVIDE A GENERAL INDICATION OF THE TYPES OF CONDITIONS LIKELY TO BE FOUND IN THE VICINITY. THE CONTRACTOR MAY AT HIS OWN EXPENSE OBTAIN ADDITIONAL GEOTECHNICAL INFORMATION.

9. ALL FIELD TESTING SHALL BE IN ACCORDANCE WITH SPECIFICATIONS AND SHALL BE PERFORMED BY THE CONTRACTOR AND APPROVED BY THE OWNER/ENGINEER PRIOR TO FINAL PAYMENT.

10. THE MINIMUM DEPTH OF COVER FOR ALL BURIED PIPES SHALL BE 36 INCHES UNLESS OTHERWISE SHOWN OR SPECIFIED. THE BEDDING BACKFILL SHALL CONFORM TO THE MINIMUM REQUIREMENTS OF THE SPECIFICATIONS.

11. CONTRACTOR SHALL CONFINE HIS WORK WITHIN THE LIMITS OF EXISTING RIGHTS-OF-WAY AND LIMITS OF CONSTRUCTION AS SHOWN ON THE DRAWINGS.

12. THROUGHOUT THESE DRAWINGS, THE CONTRACTOR WILL BE REQUIRED TO TIE-IN TO EXISTING PIPING OR RESTRAIN EXISTING PIPING. CONTRACTORS SHALL VERIFY LOCATION, SIZE AND MATERIAL OF EXISTING MAIN PRIOR TO CONSTRUCTION. NEW PIPELINES SHALL BE TESTED AND ACCEPTED PRIOR TO CONNECTION.

13. THE CONTRACTOR SHALL PROVIDE ALL DEWATERING EQUIPMENT NECESSARY TO KEEP EXCAVATIONS DRY AND SHALL PROVIDE ALL SHEETING, SHORING AND BRACING NECESSARY TO PROTECT ADJACENT STRUCTURES, UTILITIES, EXISTING PAVEMENT, OR TO MINIMIZE TRENCH WIDTH, ALL IN ACCORDANCE WITH THE SPECIFICATIONS.

14. THE CONTRACTOR SHALL PROVIDE AND INSTALL HAY BALES AND/OR SILT SCREENS AROUND THE PROPOSED CONSTRUCTION ACTIVITY, AS NECESSARY, TO PREVENT THE TRANSPORT OF SEDIMENT DOWNSTREAM INTO STREETS, STORM SEWERS, OPEN DITCHES, ETC., AND SHALL PERFORM ALL NECESSARY INSPECTIONS ALL IN ACCORDANCE WITH THE STORMWATER POLLUTION PREVENTION PLAN AND THE SPECIFICATIONS.

15. A LATERAL SEPARATION OF TEN FEET OUT SHALL BE MAINTAINED BETWEEN THE WATER MAIN AND ANY SANITARY SEWER MAINS. IN CASE OF A CROSSING, A VERTICAL SEPARATION OF NOT LESS THAN 18 INCHES SHALL BE MAINTAINED.

16. VERTICAL ALIGNMENT OF THE PROPOSED MAINS AT ALL EXISTING UTILITY CROSSINGS SHALL BE FIELD DETERMINED BY THE CONTRACTOR AND APPROVED BY THE ENGINEER.

17. THE CONTRACTOR SHALL MAINTAIN TRAFFIC AND CONTINUOUS ACCESS TO EACH BUSINESS ADJACENT TO THE WORK.

18. THE CONTRACTOR SHALL BE RESPONSIBLE FOR ANY DAMAGE CAUSED BY CONSTRUCTION OPERATIONS TO EXISTING UTILITIES WHICH HAVE BEEN FIELD LOCATED BY THEIR OWNERS.

19. THE CONTRACTOR SHALL ADHERE TO ALL CONDITIONS AND REQUIREMENTS OF ALL PERMITS, WHICH HAVE BEEN OBTAINED.

20. REFERENCE TO FDOT STANDARD SPECIFICATIONS SHALL MEAN THE CURRENT EDITION OF THE FLORIDA DEPARTMENT OF TRANSPORTATION "STANDARD SPECIFICATIONS FOR ROAD AND BRIDGE CONSTRUCTION."

JAN 9 2004

GENERAL NOTES, LEGEND AND ABBREVIATIONS

PROJECT NO. 2790-38413
FILE NAME: GNXSHOG1.DWG

EET NO.



APPLICANT

DESIGNED BY: W. SPRIGGS
DRAWN BY: T. HOLT
SHEET CHK'D BY: A. ROSS
CROSS CHK'D BY: G. CASHON
APPROVED BY: A. ROSS
DATE: AUGUST 2003

CDM Camp Dresser & McKee Inc.
consulting
engineering
construction
operations
1819 Main Street, Suite 1002
Sarasota, Florida 34236
Tel: 941-363-9696
FL Cert. of Authorization No. 20

TOWN OF LONGBOAT KEY, FLORIDA

LIFT STATION A IMPROVEMENTS

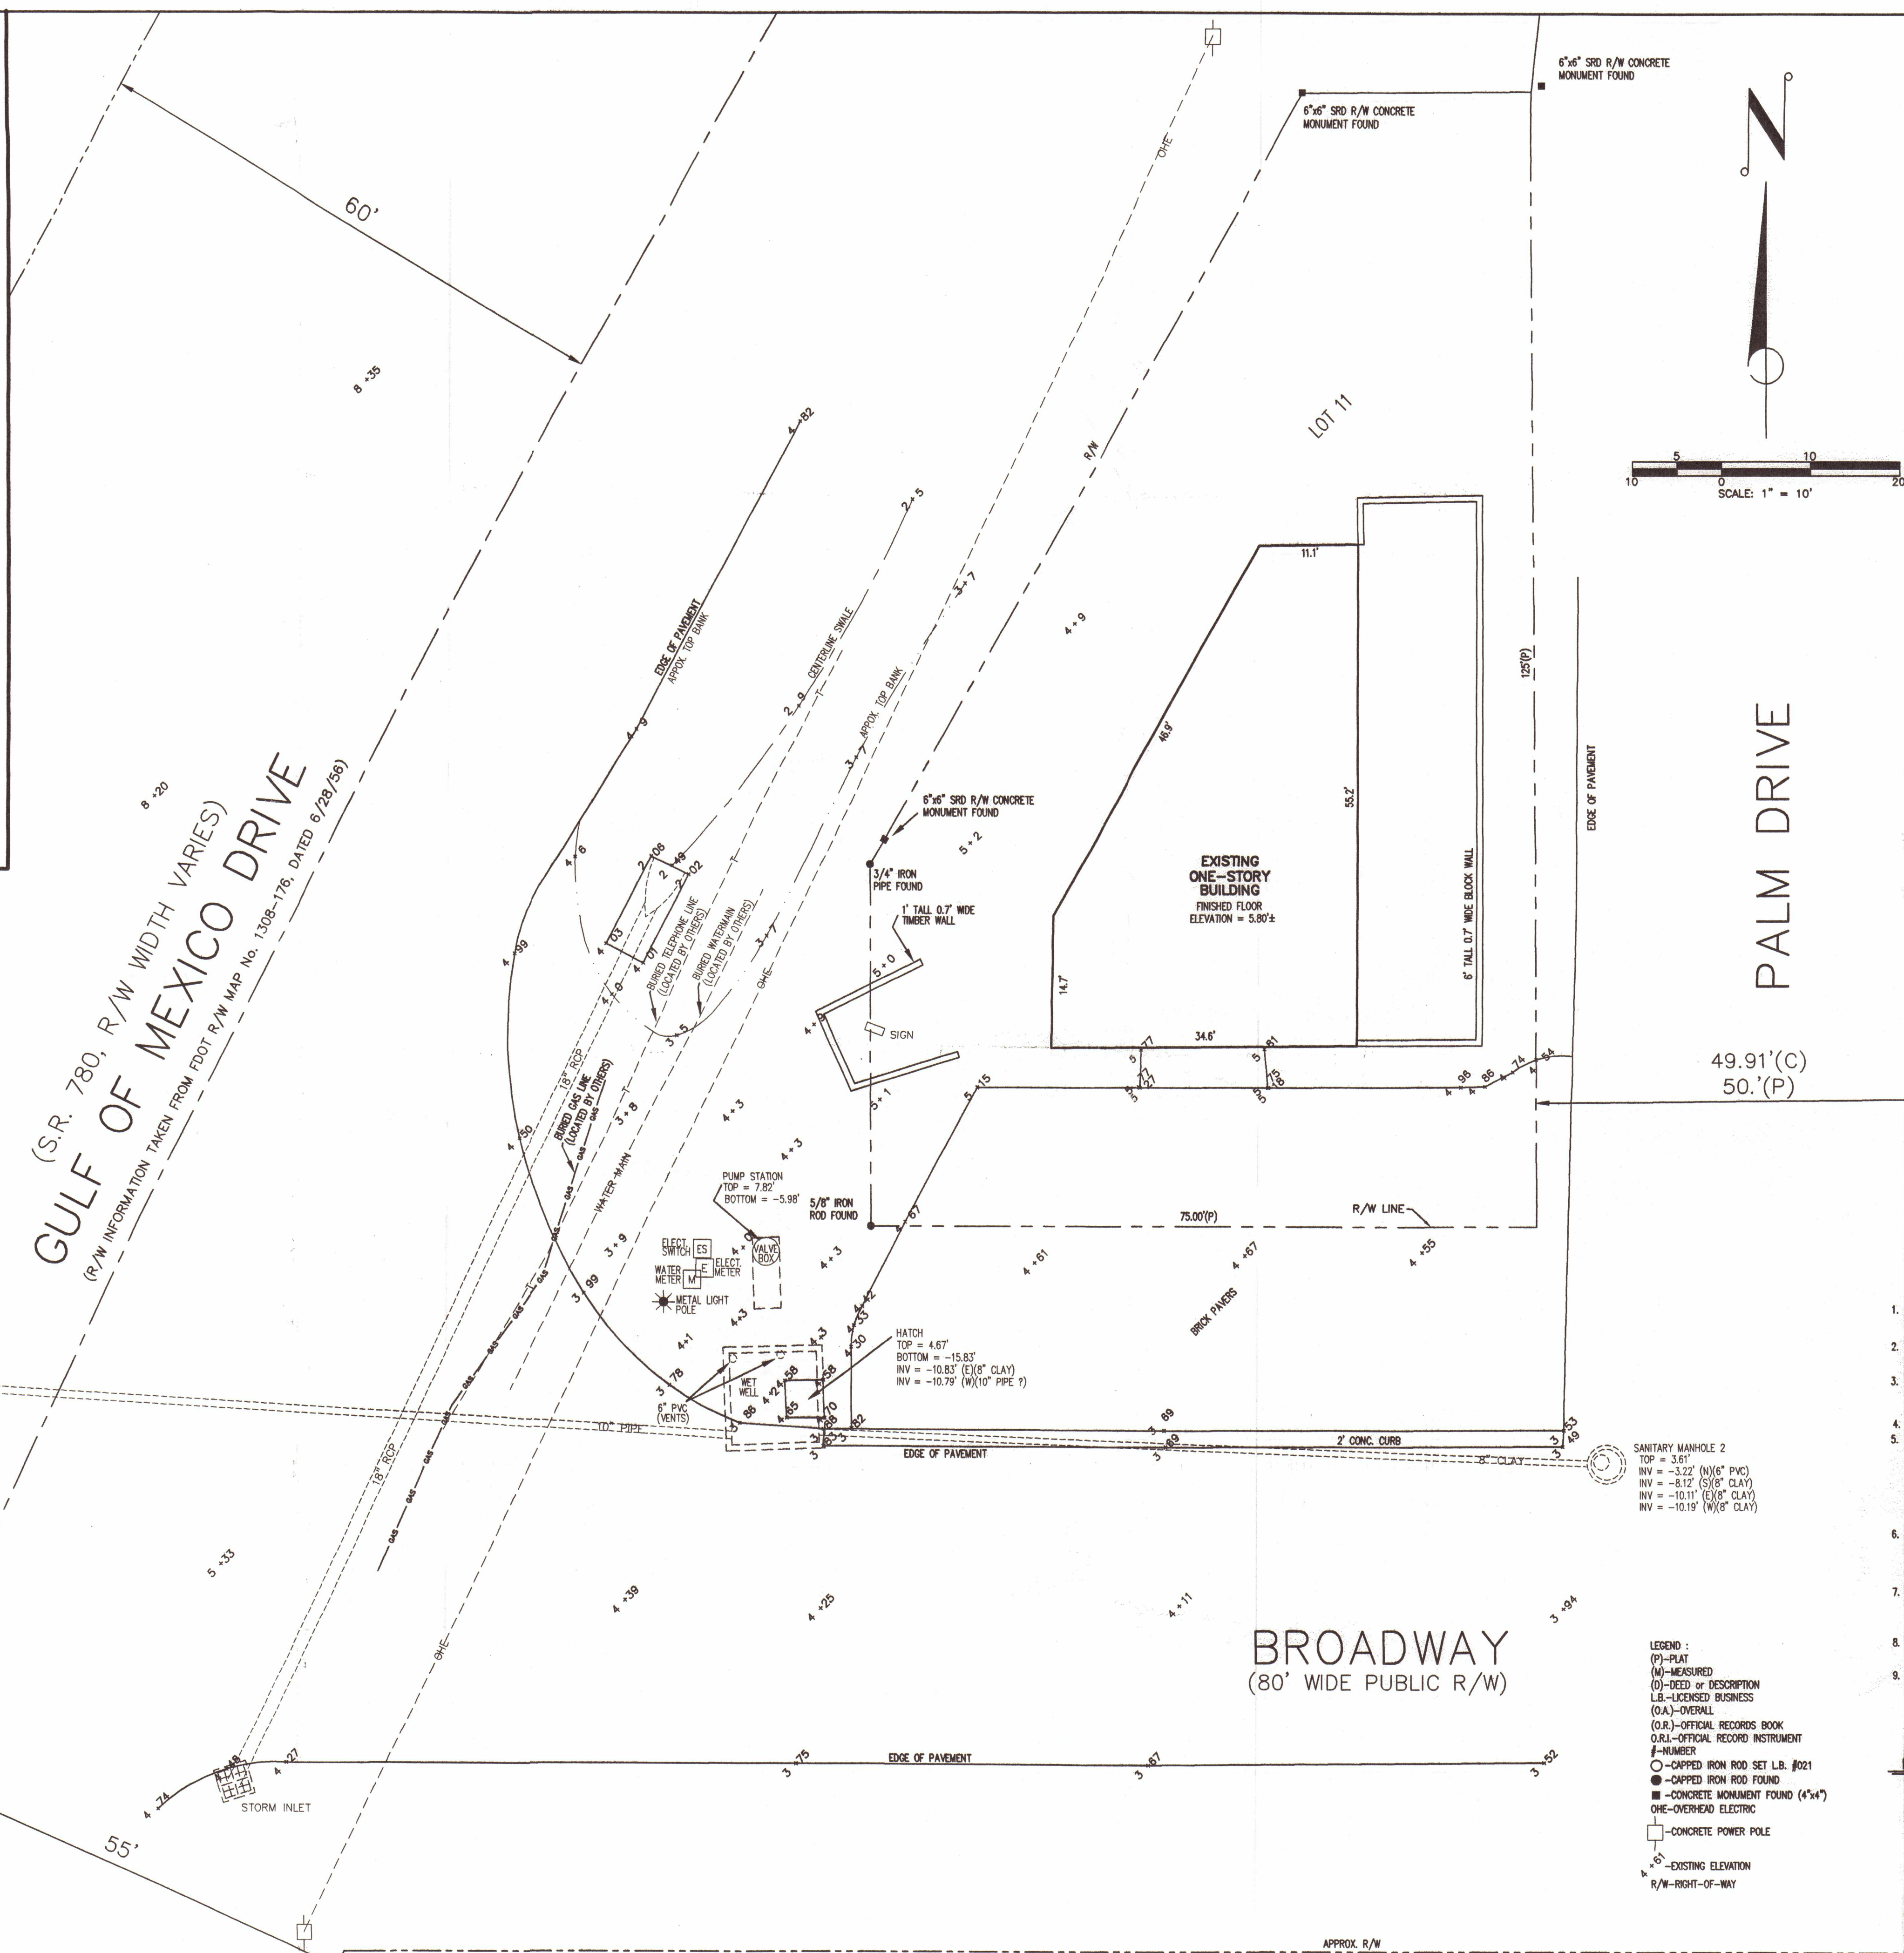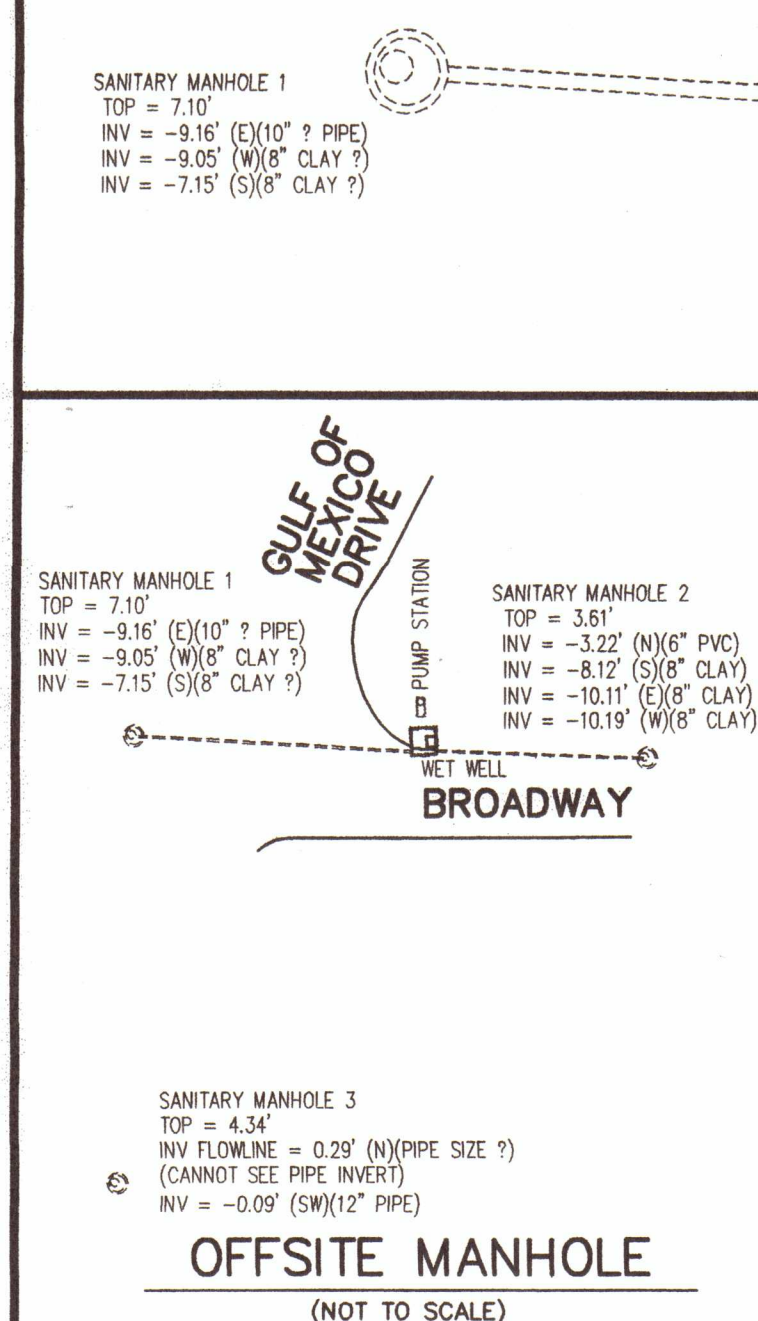

LONGBEACH
 ON LONGBOAT KEY
 (P.B. 6, PG. 66)

SURVEYOR'S REPORT

1. THIS SURVEY WAS PREPARED WITHOUT BENEFIT OF A CURRENT TITLE REPORT AND THEREFORE MAY NOT NECESSARILY INDICATE ALL ENCUMBRANCES AFFECTING SUBJECT PROPERTY.
2. THERE ARE NO VISIBLE ENCUMBRANCES EXCEPT AS SHOWN. FOUNDATIONS BENEATH THE SURFACE OF THE GROUND THAT MAY ENOUGH HAVE NOT BEEN LOCATED.
3. THE LOCATION AND EXISTENCE OF UNDERGROUND UTILITIES AND UNDERGROUND FOUNDATIONS OR ANY OTHER PERTINENT ATTRIBUTES TO SUBJECT PROPERTY (IF ANY) NOT ABSTRACTED AS PART OF THIS SURVEY, EXCEPT AS SHOWN.
4. SUBJECT TO ALL RESTRICTIONS, RIGHTS OF WAY AND EASEMENTS OF RECORD, IF ANY.
5. REUSE OF DOCUMENTS: THIS DOCUMENT IS AN INSTRUMENT OF SERVICE IN RESPECT OF THE PROJECT TO WHICH IT APPLIES AND ANY REUSE WITHOUT WRITTEN VERIFICATION OR ADAPTATION BY GEORGE F. YOUNG, INC. (G.F.Y.) FOR THE SPECIFIC PURPOSES INTENDED WILL BE AT THE USER'S SOLE RISK AND WITHOUT LIABILITY OR LEGAL REMEDY TO G.F.Y. FOR ANY SUCH REUSE OR SHALL INDEMNIFY AND HOLD HARMLESS G.F.Y. FROM ALL CLAIMS, DAMAGES, LOSSES AND EXPENSES INCLUDING ATTORNEYS FEES ARISING OUT OF OR RESULTING THEREFROM. ANY SUCH VERIFICATION OR ADAPTATION WILL ENTITLE G.F.Y. TO FURTHER COMPENSATION AT RATES TO BE AGREED UPON BY USER AND G.F.Y.
6. THE EXPECTED USE OF THE LAND, AS CLASSIFIED IN THE FLORIDA MINIMUM TECHNICAL STANDARDS (61017-6-F.A.C.), IS SUBURBAN. THE MINIMUM RELATIVE DISTANCE ACCURACY FOR THIS TYPE OF BOUNDARY SURVEY IS 1 FOOT IN 7,500 FEET. THE ACCURACY ESTABLISHED BY MEASUREMENT AND CALCULATION OF A CLOSED GEOMETRIC FIGURE FOR THIS SURVEY WAS FOUND TO EXCEED THIS REQUIREMENT.
7. ELEVATIONS SHOWN WERE BASED ON F.D.O.T. BENCH MARK BM #72, BRASS DISK IN A CONCRETE MONUMENT LOCATED EAST OF GULF OF MEXICO DRIVE AND NORTH OF BROADWAY, WITH A PUBLISHED ELEVATION OF 4.796', NATIONAL VERTICAL DATUM OF 1929.
8. SUNSHINE STATE ONE CALL CENTER (TICKET NO. 0973215) WAS CONTACTED TO FLAG UNDERGROUND UTILITIES. NO OTHER INVESTIGATION WAS MADE CONCERNING UNDERGROUND UTILITIES.
9. THE SPECIFIC PURPOSE OF THIS SURVEY IS TO PROVIDE THE DESIGN INFORMATION WITH TOPOGRAPHIC INFORMATION IN RELATIONSHIP TO THE EXISTING LOT STATION AND VICINITY THEREOF FOR IMPROVEMENTS.

I HEREBY CERTIFY: THAT THIS SPECIFIC PURPOSE SURVEY REPRESENTS A FIELD SURVEY PERFORMED ON APRIL 10, 2003 UNDER MY DIRECTION AND THAT IT MEETS THE MINIMUM TECHNICAL STANDARDS FOR SURVEYING IN THE STATE OF FLORIDA AS SET FORTH BY THE FLORIDA BOARD OF LAND SURVEYORS, PURSUANT TO CHAPTER 472 OF THE FLORIDA STATUTES AND CHAPTER 61G17-6 OF THE FLORIDA ADMINISTRATIVE CODE.

GEORGE F. YOUNG, INC.
(LICENSED BUSINESS #021)
78 SARASOTA CENTER BLVD
SARASOTA, FLORIDA 34240


DENNIS R. HOOVER
PROFESSIONAL LAND SURVEYOR
FLORIDA CERTIFICATE #4419

FIELD BOOK
PAGE

THIS SURVEY IS NOT VALID WITHOUT THE SIGNATURE AND THE ORIGINAL RAISED SEAL OF A FLORIDA LICENSED SURVEYOR AND MAPPER

TOWN OF LONGBOAT KEY
LIFT STATION "A"
SPECIFIC PURPOSE SURVEY

JOB NO.
0373002500

SP-1

APPLICAN

REVISED					REVISED				
NO.	BY	DATE	DESCRIPTION		NO.	BY	DATE	DESCRIPTION	
1					6				
2					7				
3					8				
4					9				
5					10				

Y George F. Young, Inc.
ARCHITECTURE • ENGINEERING • ENVIRONMENTAL • LANDSCAPE • PLANNING • SURVEYING • UTILITIES
BRADENTON • GAINESVILLE • NORTH PALM BEACH • ST. PETERSBURG • SARASOTA • TAMPA
ENGINEERING STATE BUSINESS NO. EB-0000021 SURVEYING STATE BUSINESS NO. LB-000002
78 SARASOTA CENTER BOULEVARD SARASOTA, FLORIDA 34240
Since 1919 PHONE (941) 371-6362 • FAX (941) 378-3215 • E-MAIL info@georgefyoung.com

DENNIS R. HOOVER, PSM No. 4419	TASK	INITIALS	DATE
	DESIGN		
	DRAWN	P.L.	04/15/0
	CHECKED	D.R.H.	04/15/0
	QUALITY CHK.		
DATE	SCALE	1"=10'	

PREPARED FOR:
C.D.M.
1819 MAIN ST., Suite 1002
SARASOTA, FL. 34236

**TOWN OF LONGBOAT KEY
LIFT STATION "A"
SPECIFIC PURPOSE SURVEY** JAN 9 2004